

# AT&T SITE NUMBER: CCL05072 AT&T SITE NAME: SACRED HEART

10189 SHORELINE HIGHWAY
POINT REYES STATION, CA 94956
JURISDICTION: CITY OF OLEMA
APN: 166-181-01

# SITE TYPE: EQUIPMENT SHELTER / TOWER

# INITIATIVE/PROJECT: NSB

USID #: 323586 FA LOCATION CODE: 15906580

RFDS ID: 5440194 RFDS VERSION: 2.00 RFDS DATE: 09/29/2023 PACE JOB #: MRSFR099043

PTN #: **3701A17A7G** 

# PROJECT DESCRIPTION

A (N) AT&T UNMANNED TELECOMMUNICATION FACILITY CONSISTING OF INSTALLING:

- INSTALLATION OF (3) AT&T PANEL ANTENNAS MOUNTED AT A 76'-0" CENTERLINE ((1) PER SECTOR)
- INSTALLATION OF (3) AT&T PANEL ANTENNAS MOUNTED AT A 69'-0" CENTERLINE ((1) PER SECTOR)
   INSTALLATION OF (9) AT&T REMOTE RADIO HEADS (RRHS) ((3) PER SECTOR)
- INSTALLATION OF (3) NEW AT&T TOWER MOUNTED DC-9 SURGE SUPPRESSORS
- INSTALLATION OF AT&T 3'-0" HIGH RAISED STEEL PLATFORM
- INSTALLATION OF (1) AT&T GPS UNIT MOUNTED ON PROPOSED OUTDOOR EQUIPMENT CABINET
- (1) VERTIV STD-48DC OUTDOOR NETSURE 5100 POWER PLANT WITH (3) STRINGS OF 180AH BATTERIES, (9) -48V RECTIFIERS & (9) -58V CONVERTERS
- (1) PURCELL CABINET FLEX21 FOR BBU EQUIPMENT
- (2) OUTDOOR BATTERY CABINET WITH (20) SBS190F BATTERIES EA.
- INSTALLATION OF NEW AT&T 8' TALL SLUMP STONE WALL
   INSTALLATION OF (2) AT&T 4' WIDE WOODEN GATE
- INSTALLATION OF (2) AT&T 4" WIDE WOODEN GATE
   INSTALLATION OF (1) AT&T CIENA AND (1) HOFFMAN BOX MOUNTED TO BLOCK WALL

SAN FRANCISCO, CALIFORNIA 94109


(415) 292-0802

JOHN P. CHRISTIAN, EXECUTIVE DIRECTOR

- INSTALLATION OF A 200A DEDICATED SERVICE TO METER MOUNTED TO BLOCK WALL
- INSTALLATION OF (1) AT&T CAM LOCK GEN PLUG
   INSTALLATION OF NEW TOWER EQUIPMENT PLATFORM
- INSTALLATION OF NEW PG&E TRANSFORMER ON A CONCRETE PAD
- INSTALLATION OF (6) PG&E BOLLARDS
   INSTALLATION OF (2) PG&E CONDUITS

### PROJECT INFORMATION

SITE NAME:	SACRED HEART	APPLICANT:	AT&T MOBILITY 5001 EXECUTIVE PARKWAY
SITE #:	CCL05072		SAN RAMON, CALIFORNIA 94583
COUNTY:	MARIN COUNTY	SITE ACQUISITION COMPANY:	MODUS LLC 240 STOCKTON STREET
JURISDICTION:	CITY OF OLEMA		SAN FRANCISCO, CALIFORNIA 94108
APN :	166-181-01	LEASING CONTACT:	ATTN: LORRIE BILLALON (510) 825-8889
SITE ADDRESS:	10189 SHORELINE HIGHWAY POINT REYES STATION, CA 94956		LBILLALON@MODUSLLC.COM
CURRENT ZONING:	C-VCR - VILLAGE COMMERCIAL RESIDENTIAL	ZONING CONTACT:	ATTN: ERIC LENTZ (805) 895-4394
			LENTZPLANNING@GMAIL.COM
CONSTRUCTION TYPE:	V-B	CONSTRUCTION CONTACT:	ATTN: KEITH CONNER
OCCUPANCY TYPE:	U, (UNMANNED COMMUNICATIONS FACILITY)		(408) 306-3801 GKCONNER@BECHTEL.COM
POWER:	PG&E		
LATITUDE:	N 38° 02' 40.3" NAD 83 38.0445140° NAD 83		
LONGITUDE:	W 122° 47' 27.0" NAD 83 -122.7907530° NAD 83		
GROUND ELEVATION:	±47.97' AMSL		
PROPERTY OWNER:	ARCHDIOCESE OF SAN FRANCISCO PARISH & SCHOOL 1301 POST STREET, STE 102		

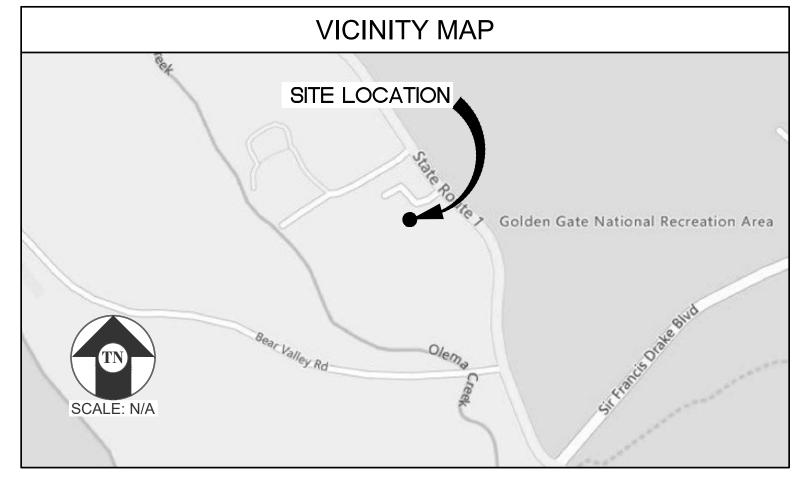

### DRIVING DIRECTIONS

FROM: TO:	5001 EXECUTIVE PARKWAY, SAN RAMON, CALIFORNIA 94583 10189 SHORELINE HIGHWAY, POINT REYES STATION, CALIFORNIA 94956	
2. TURN 3. TURN 4. TURN 5. TURN 6. TURN 7. USE T 8. USE T 9. MERG 10. USE T 11. CONTI 12. KEEP 13. TAKE 14. TAKE 15. USE T 16. CONTI 17. MERG 18. TAKE 19. CONTI 20. TURN 21. SLIGH 22. TURN 23. CONTI 24. TURN 25. TURN 26. TURN 27. DEST	LEFT TOWARD EXECUTIVE PKWY RIGHT TOWARD EXECUTIVE PKWY RIGHT ONTO EXECUTIVE PKWY LEFT ONTO CAMINO RAMON HE LEFT 2 LANES TO TURN LEFT ONTO CROW CANYON RD HE RIGHT 2 LANES TO TURN LEFT ONTO I-680 N VIA THE RAMP TO SACRAMENTO E ONTO I-680 N HE RIGHT 2 LANES TO TAKE EXIT 46A FOR STATE ROUTE 24 TOWARD OAKLAND/LAFAYETTE INUE ONTO CA-24 W LEFT TO STAY ON CA-24 W EXIT 2B TO MERGE ONTO I-580 W TOWARD SAN FRANCISCO THE EXIT ONTO I-580 W/I-80 E TOWARD BERKELEY/SACRAMENTO HE RIGHT 2 LANES TO TAKE EXIT 13B FOR I-580 TOWARD SAN RAFAEL/POINT RICHMOND INUE ONTO I-580 W E ONTO US-101 N EXIT 456 FOR LUCAS VALLEY RD INUE ONTO LUCAS VALLEY RD RIGHT ONTO NICASIO VALLEY RD RIGHT ONTO NICASIO VALLEY RD LEFT TO STAY ON NICASIO VALLEY RD INUE ONTO PT. REYES - PETALUMA RD INUE ONTO PT. REYES - PETALUMA RD INUE ONTO PLATFORM BRIDGE RD RIGHT ONTO SIR FRANCIS DRAKE BLVD RIGHT ONTO CA-1 N LEFT INATION WILL BE ON THE LEFT	33 FT 312 FT 164 FT 295 FT 0.2 MI 0.8 MI 0.2 MI 1.1 MI 8.1 MI 4.3 MI 1.5 MI 4.3 MI 0.5 MI 13.0 MI 4.3 MI 0.3 MI 10.3 MI 10.3 MI 2.4 MI 3.0 MI 2.4 MI 3.0 MI 3.5 FT
END AT:	10189 SHORELINE HIGHWAY, POINT REYES STATION, CALIFORNIA 94956  D TIME: 1 HOUR 22 MINUTES ESTIMATED DISTANCE: 70.3 MILES	

### CODE COMPLIANCE

ALL WORK & MATERIALS SHALL BE PERFORMED & INSTALLED IN ACCORDANCE WITH THE CURRENT EDITIONS OF THE FOLLOWING CODES AS ADOPTED BY THE LOCAL GOVERNING AUTHORITIES. NOTHING IN THESE PLANS IS TO BE CONSTRUED TO PERMIT WORK NOT CONFORMING TO H=THESE CODES:

### 2022 CALIFORNIA ADMINISTRATIVE CODE, PART 1, TITLE 24 C.C.R

- 2022 CALIFORNIA BUILDING CODE (CBC), PART 2, VOLUME 1&2, TITLE 24 C.C.R.
- (2021 INTERNATIONAL BUILDING CODE AND 2022 CALIFORNIA AMENDMENTS)
  2022 CALIFORNIA ELECTRICAL CODE (CEC), PART 3, TITLE 24 C.C.R.
- (2020 NATIONAL ELECTRICAL CODE AND 2022 CALIFORNIA AMENDMENTS)
- 2022 CALIFORNIA MECHANICAL CODE (CMC) PART 4, TITLE 24 C.C.R. (2021 UNIFORM MECHANICAL CODE AND 2022 CALIFORNIA AMENDMENTS)
- 2022 CALIFORNIA PLUMBING CODE (CPC), PART 5, TITLE 24 C.C.R.
  2021 UNIFORM PLUMBING CODE AND 2022 CALIFORNIA AMENDMENTS)
- 2021 UNIFORM PLUMBING CODE AND 2022 CALIFORNIA AMENDMENTS)
  2022 CALIFORNIA ENERGY CODE (CEC), PART 6, TITLE 24 C.C.R.
- 2022 CALIFORNIA FIRE CODE, PART 9, TITLE 24 C.C.R.
  (2021 INTERNATIONAL FIRE CODE AND 2022 CALIFORNIA AMENDMENTS)
- 2022 CALIFORNIA GREEN BUILDING STANDARDS CODE, PART 11, TITLE 24 C.C.R. 2022 CALIFORNIA REFERENCE STANDARDS, PART 12 TITLE 24 C.C.R.
- ANSI/EIA-TIA-222-H ALONG WITH ANY OTHER APPLICABLE LOCAL & STATE LAWS AND REGULATIONS

### DISABLED ACCESS REQUIREMENTS

THIS FACILITY IS UNMANNED & NOT FOR HUMAN HABITATION. DISABLED ACCESS & REQUIREMENTS ARE NOT REQUIRED IN ACCORDANCE WITH CALIFORNIA STATE BUILDING CODE, TITLE 24 PART 2, SECTION 11B-203.5

### SHEET INDEX

	OHLL! INDLX	
SHEET NO.	DESCRIPTION	REV
T-1	TITLE SHEET	3
T-2	SITE SIGNAGE	3
T-3	BATTERY SPECIFICATIONS	3
T-4	FEMA FLOOD ZONE MAP	3
T-5	EROSION & SEDIMENT CONTROL	3
C-1	TOPOGRAPHIC SURVEY	3
A-1	OVERALL SITE PLAN	3
A-1.1	ENLARGED SITE PLAN	3
A-2	SITE DETAIL	3
A-2.1	SITE DETAIL WITH DIMENSIONS	3
A-3	ANTENNA PLAN AND EQUIPMENT SCHEDULE	3
A-4	EXISTING AND PROPOSED NORTHEAST ELEVATIONS	3
A-5	EXISTING AND PROPOSED SOUTHEAST ELEVATIONS	3
A-6	ARCHITECTURAL NORTHEAST AND SOUTHEAST ELEVATIONS	3
D-1	EQUIPMENT DETAILS	3
D-2	EQUIPMENT DETAILS	3
E-1	UTILITY ROUTING, PANEL SCHEDULE, SINGLE LINE DIAGRAM & NOTES	3
E-2	ELECTRICAL DETAILS	3

#### PROJECT INFORMATION:

### CCL05072 SACRED HEART

10189 SHORELINE HIGHWAY POINT REYES STATION, CA 94956

#### PREPARED FOR



5001 EXECUTIVE PARKWAY SAN RAMON, CALIFORNIA 94583

#### VENDO



4850 WEST OQUENDO ROAD LAS VEGAS, NEVADA 89118 PHONE: (702) 367-7705 FAX: (702) 367-8733

#### AT&T SITE NO: CCL05072

PROJECT NO: -

DRAWN BY: M. MARASIGAN

CHECKED BY: B. OXBORROW

APPROVED BY: C. WENER

# ISSUE STATUS

1	ISSUE STATUS					
	REV.	DATE	DESCRIPTION	BY		
	0	12/01/22	90% ZONING	M.N		
	1	04/17/23	100% ZONING	M.N		
	2	02/07/24	CLIENT REVISION	M.N		
	3	02/14/24	PLAN CHECK	M.N		


### LICENSURE:

PRELIMINARY:
NOT FOR
CONSTRUCTION


IT IS A VIOLATION OF LAW FOR ANY PERSON, UNLESS THEY ARE ACTING UNDER THE DIRECTION OF A LICENSED PROFESSIONAL ENGINEER, TO ALTER THIS DOCUMENT.

SHEET TITLE:

TITLE SHEET

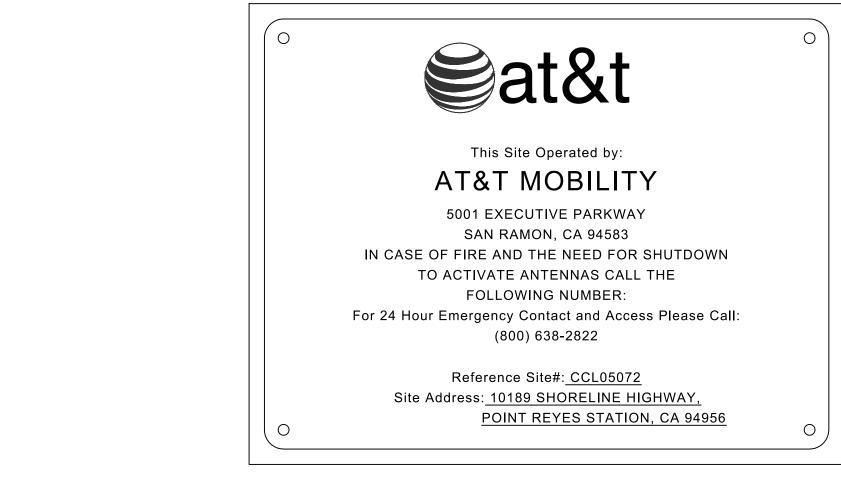


FOR FUEL & OTHER ENVIRONMENTAL **EMERGENCIES** CALL EH&S 1-800-566-9347 1-800-KNOW-EHS

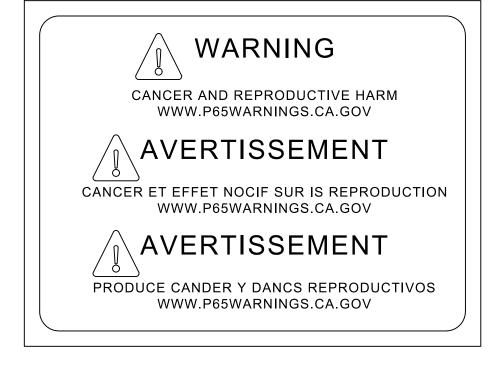


SIGNAGE AND STRIPING INFORMATION

- THE FOLLOWING INFORMATION IS A GUIDELINE WITH RESPECT TO PREVAILING STANDARDS LIMITING HUMAN EXPOSURE TO RADIO FREQUENCY ENERGY AND SHOULD BE USED AS SUCH. IF THE SITE'S EMF REPORT OR ANY LOCAL, STATE OR FEDERAL GUIDELINES OR REGULATIONS SHOULD BE IN CONNECT WITH ANY PART OF THESE NOTES OR PLANS, THE MORE RESTRICTIVE GUIDELINE OR REGULATION SHALL BE FOLLOWED AND OVERRIDE THE LESSER.
- THE PUBLIC LIMIT OF RF EXPOSURE ALLOWED BT AT&T IS 1mWcm\*2 AND THE OCCUPATIONAL LIMIT OF RF EXPOSURE ALLOWED BY AT&T IS 5mWcm\*2.
- IF THE BOTTOM OF THE ANTENNA IS MOUNTED (8) EIGHT FEET ABOVE THE GROUND OR WORKING PLATFORM LINE OF THE PERSONAL COMMUNICATION SYSTEM (PCS) AND DOES NOT EXCEED THE PUBLIC LIMIT OF RF EXPOSURE LIMIT THEN NO STRIPING OR BARRICADES SHOULD BE NEEDED
- IF THE PUBLIC LIMIT OF RF EXPOSURE ON THE SITE IS EXCEEDED AND THE AREA IS PUBLICLY ACCESSIBLE (e.g. ROOF ACCESS DOOR THAT CANNOT BE LOCKED, OR THE ANTENNAS. THE EXACT EXTENT OF THE BARRICADES AND STRIPING SHALL BE AFTER COMPLETION OF THE SITE CONSTRUCTION. USE THE PLANS AS A GUIDELINE FOR PLACEMENT OF SUCH BARRICADES AND STRIPING.
- IF THE PUBLIC LIMIT OF RF EXPOSURE ON THE SITE IS EXCEEDED AND THE AREA IS PUBLICLY ACCESSIBLE (e.g. ROOF ACCESS DOOR THAT CANNOT BE LOCKED, OR FIRE EGRESS) THEN BOTH BARRICADES AND STRIPING SHALL BE PLACED AROUND THE ANTENNAS. THE EXACT EXTENT OF THE BARRICADES AND STRIPING SHALL BE PLACED AROUND THE ANTENNAS, THE EXACT EXTENT OF THE BARRICADES & STRIPING SHALL BE DETERMINED BY THE EMF REPORT FOR THE SITE DONE BEFORE OR SHORTLY AFTER COMPLETION OF SITE CONSTRUCTION. USE THE PLANS AS A GUIDELINES FOR PLACEMENT OF SUCH BARRICADES AND STRIPING ALL TRANSMIT ANTENNAS REQUIRE A THREE LANGUAGE WARNING SIGN WRITTEN
- IN ENGLISH, SPANISH, AND CHINESE. THIS SIGN SHALL BE PROVIDED TO THE CONTRACTOR Y THE AT&T CONSTRUCTION PROJECT MANAGER AT THE TIME OF CONSTRUCTION. THE LARGER SIGN SHALL BE PLACED IN PLAIN SIGHT AT ALL ROOF ACCESS LOCATIONS AND ON ALL BARRICADES. THE SMALLER SIGN SHALL BE PLACED ON THE ANTENNA ENCLOSURES IN A MANNER THAT IS EASILY SEEN BY ANY PERSON ON THE ROOF. WARNING SIGNS SHALL COMPLY WITH ANSI C95.2 COLOR, SYMBOL, AND CONTENT CONVENTIONS. ALL SIGNS SHALL HAVE AT&T'S NAME AND THE COMPANY CONTACT INFORMATION (e.g. TELEPHONE NUMBER) TO ARRANGE FOR ACCESS TO THE RESTRICTED AREAS. THIS TELEPHONE NUMBER SHALL BE PROVIDED TO THE CONTRACTOR BY THE AT&T CONSTRUCTION PROJECT MANAGER AT THE TIME OF CONSTRUCTION.
- PHOTOS OF ALL STRIPING, BARRICADES AND SIGNAGE SHALL BE PART OF THE CONTRACTORS CLOSE OUT PACKAGE & SHALL BE TURNED INTO THE AT&T CONSTRUCTION PACKAGE & SHALL BE TURNED INTO THE AT&T CONSTRUCTION MANAGER AT THE END OF CONSTRUCTION. STRIPING SHALL BE DONE WITH FADE RESISTANT YELLOW SAFETY PAINT IN A CROSS-HATCH PATTERN AS DETAILED BY THE CONSTRUCTION DRAWINGS. ALL BARRICADES SHALL BE MADE OF AN RF FRIENDLY MATERIAL SO AS NOT TO BLOCK OR INTERFERE WITH THE OPERATION OF THE ANTENNAS. BARRICADES SHALL BE PAINTED WITH FADE RESISTANT YELLOW SAFETY PAINT. THE CONTRACTOR SHALL PROVIDE WITH ALL RF FRIENDLY BARRICADES NEEDED, & SHALL PROVIDE THE AT&T CONSTRUCTION PROJECT MANAGER WITH A DETAILED SHOP DRAWING OF EACH BARRICADES. UPON CONSTRUCTION COMPLETION.

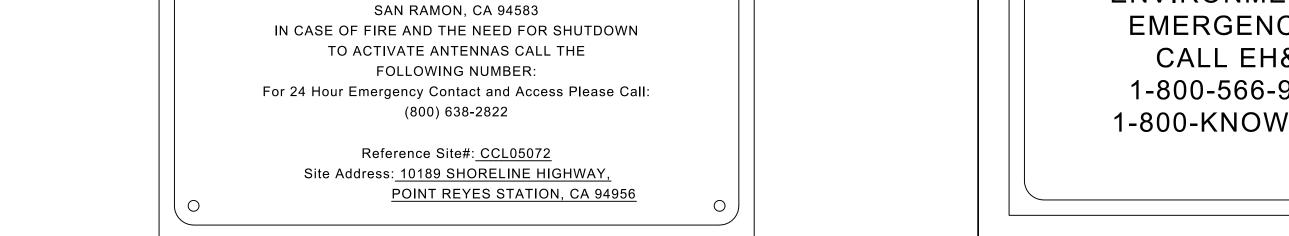

DANGER


FENCE COMPOUND SIGNAGE

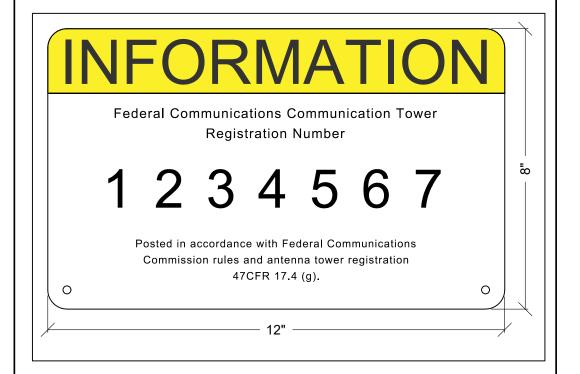

# **DIESEL FUEL**

COMBUSTIBLE NO SMOKING NO OPEN FLAMES

FUEL TANK CAPACITY 190 GALS

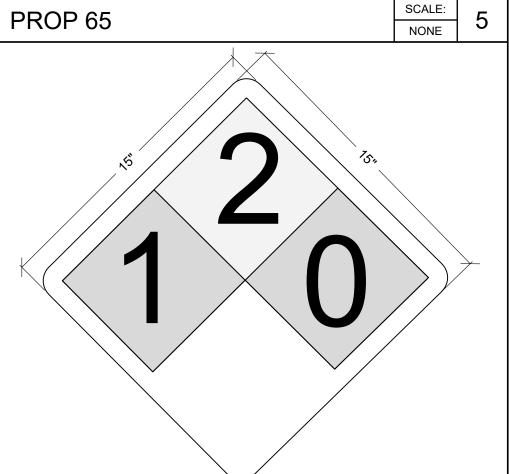

TRESPASSING

FENCED COMPOUND SIGNAGE

FCC ASR SIGNAGE

**FUEL TYPE SIGN** 

YELLOW EH&S SIGN

NFPA 704 HAZARD DIAMOND SIGN

**GENERAL NOTES** 

NONE

0 12/01/22 90% ZONING 04/17/23 100% ZONING 02/07/24 CLIENT REVISION PLAN CHECK 02/14/24

PROJECT INFORMATION:

CCL05072

SACRED HEART

10189 SHORELINE HIGHWAY

POINT REYES STATION, CA 94956

PREPARED FOR

5001 EXECUTIVE PARKWAY

SAN RAMON, CALIFORNIA 94583

SPECTRUM SERVICES, LLC

4850 WEST OQUENDO ROAD

LAS VEGAS, NEVADA 89118

PHONE: (702) 367-7705

FAX: (702) 367-8733

M. MARASIGAN

DESCRIPTION

AT&T SITE NO: CCL05072

CHECKED BY: B. OXBORROW

**ISSUE STATUS** 

APPROVED BY: C. WENER

PROJECT NO: -

DATE

LICENSURE:

DRAWN BY:

**VENDOR:** 

NOTICE AUTHORIZED PERSONNEL ONLY

Property of AT&T

# Authorized Personnel Only

No Trespassing Violators will be prosecuted

In case of emergency, or prior to performing maintenance on this site, call (800) 638-2822 and reference cell site number <u>CCL05072</u>

1. CONTRACTOR SHALL INSTALL ALL INFORMATION SIGNAGE IN ACCORDANCE W/ AT&T WIRELESS DOCUMENT #03-0074, RF EXPOSURE POLICY AND RF SAFETY COMPLIANCE PROGRAM LATEST EDITION.

2. CONTRACTOR SHALL CONTACT AT&T R-RFSC FOR INFORMATION ON MPE LEVELS AND INSTRUCTIONS ON LEVEL AND LOCATION OF SIGNAGE.

DOOR / EQUIPMENT SIGN

NFPA HAZARD SIGN

**GATE SIGNAGE** 

SCALE: 9

ACID

Property of AT&T

# Authorized Personnel Only

In case of emergency, or prior to performing maintenance on this site, call (800) 638-2822 and reference cell site number CCL05072



 


On this tower: Beyond This Point you are entering an area where radio frequency (RF) fields may exceed the FCC General Population Exposure Limits. Contact AT&T at 800-638-2822 and follow their instructions prior to performing any maintenance or repairs above this point.

Personal climbing this tower should be trained for working in RF environment and used a personal RF monitoring if working near active antennas.

O Caution sign #CAOTT-ALL-057 This is AT&T site CCL05072

O Caution sign #CAOTT-ALL-057 This is AT&T site CCL05072





AT&T operates antennas at this site. Beyond This Point you are entering an area where radio frequency (RF) fields may exceed the FCC General Population Exposure Limits. Follow safety guidelines for working in an RF environment. Contact AT&T at 800-638-2822 and follow their

instructions prior to performing any maintenance or repairs above this point.

O Caution sign #CAOTT-ALL-057 This is AT&T site CCL05072

CABINET DOORS SIGNAGE **CAUTION AND WARNING SIGN** 

SHEET TITLE:

SITE SIGNAGE

IT IS A VIOLATION OF LAW FOR ANY PERSON

UNLESS THEY ARE ACTING UNDER THE

DIRECTION OF A LICENSED PROFESSIONAL

ENGINEER, TO ALTER THIS DOCUMENT.

PRELIMINARY:

NOT FOR

CONSTRUCTION

or repairs above this point.

AT&T operates antennas at this site.

Beyond This Point you are entering an area

where radio frequency (RF) fields may exceed

the FCC General Population Exposure Limits.

Follow safety guidelines for working in an RF


Contact AT&T at 800-638-2822 and follow their


instructions prior to performing any maintenance

**NOTICE SIGN** 


SCALE: NONE




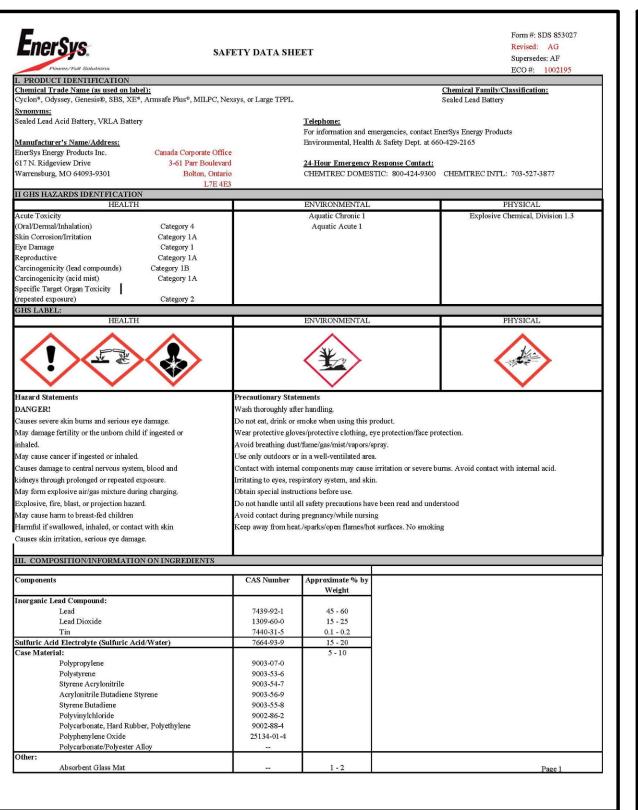

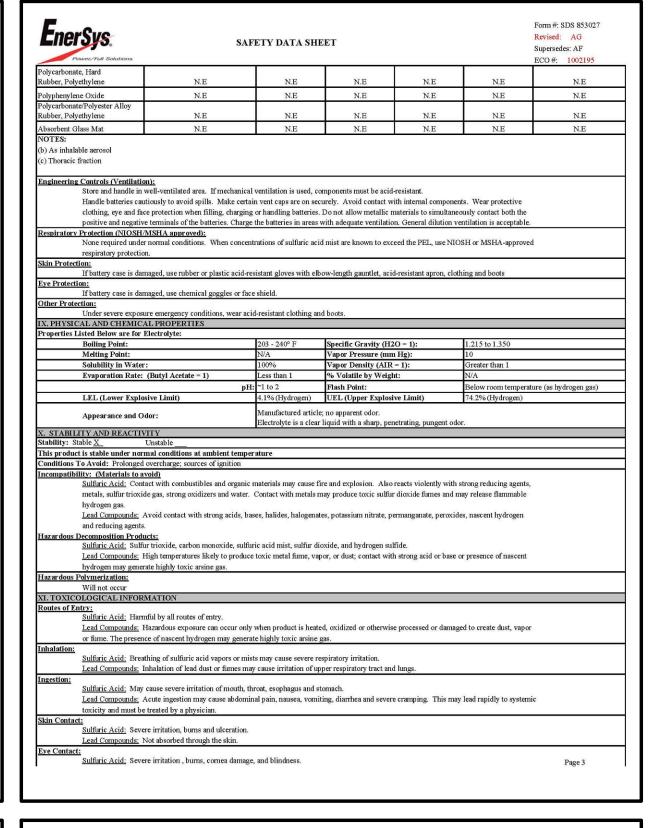



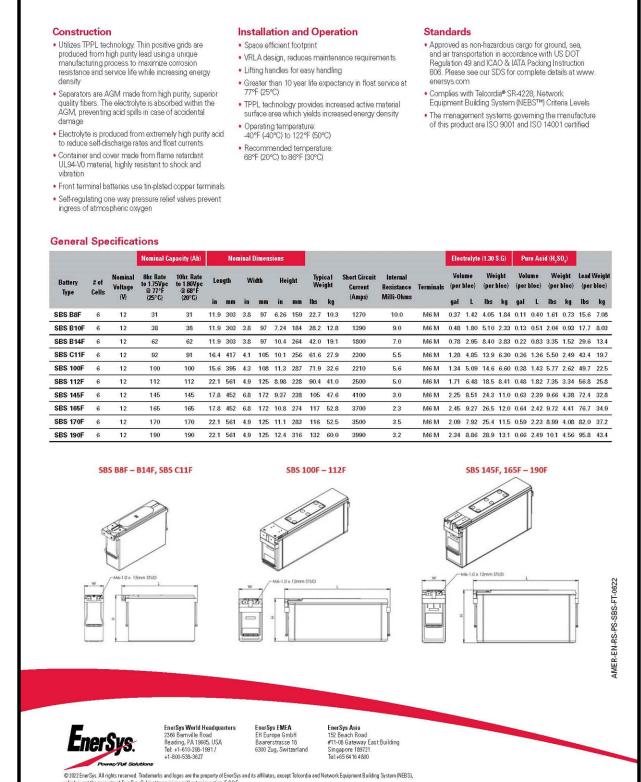


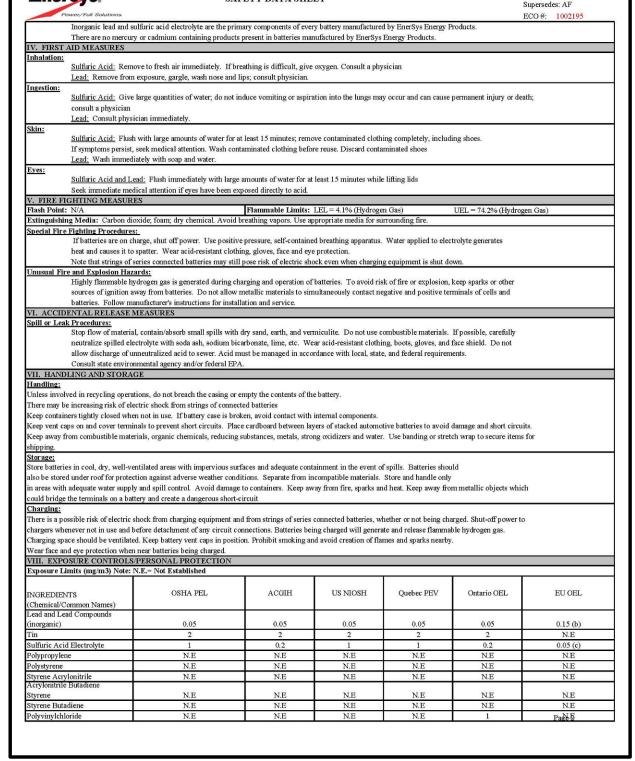

SAFETY DATA SHEET

**EnerSys**.



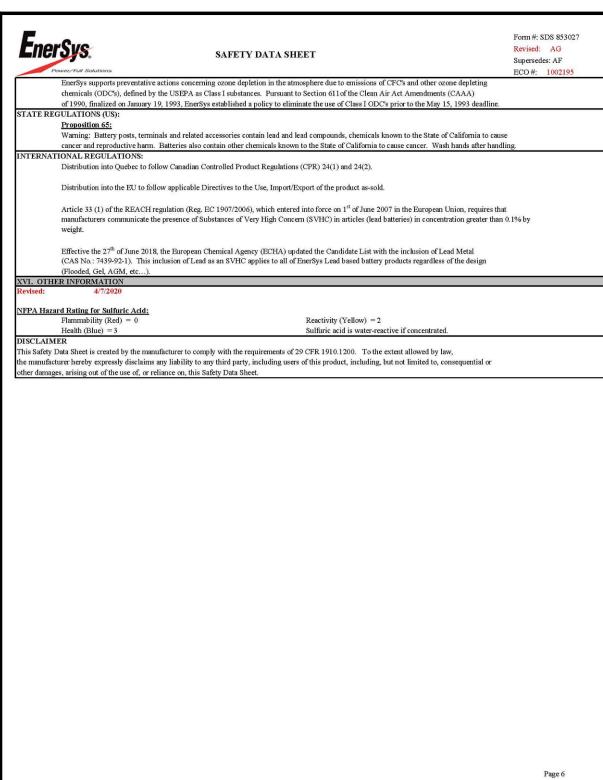

	BATTERY INFORMATION						
BATTERY MODEL	TOTAL # OF BATTERY UNITS INSTALLED	TOTAL ELECTROLYTE VOLUME (GAL) PER UNIT	TOTAL ELECTROLYTE WEIGHT (LBS) PER UNIT	% SULFURIC = <u>ACID VOLUME / UNIT</u> ACID BY VOL ELECTROLYTE VOLUME/UNIT	% SULFURIC = <u>TOTAL ACID WEIGHT</u> ACID BY WEIGHT TOTAL ELECTROLYTE WEIGHT	TOTAL SULFURIC = TOTAL UNITS X VOL (GAL) SULFURIC VOL/UNIT	% SULFURIC = <u>ACID VOLUME / UNIT</u> ACID BY VOL ELECTROLYTE VOLUME/UNIT
POWERSAFE - SBS190F	20 UNITS	2.34 GAL	28.9 LBS	28.21% = 0.66 GAL / 2.34 GAL	34.95% = 10.1 LBS/28.9 LBS	46.8 GAL = 20 UNITS X 2.34 / UNIT	323.2 LBS = 20 UNITS X 10.1 LBS

PROJECT INFORMATION:

CCL05072 SACRED HEART

10189 SHORELINE HIGHWAY POINT REYES STATION, CA 94956

PREPARED FOR



5001 EXECUTIVE PARKWAY SAN RAMON, CALIFORNIA 94583

VENDOR:

SPECTRUN

A Nextedge Company

SPECTRUM SERVICES, LLC.

4850 WEST OQUENDO ROAD LAS VEGAS, NEVADA 89118 PHONE: (702) 367-7705 FAX: (702) 367-8733

AT&T SITE NO: CCL05072

PROJECT NO: -

DRAWN BY: M. MARASIGAN

CHECKED BY: B. OXBORROW

APPROVED BY: C. WENER

ISSUE STATUS					
REV.	DATE	DESCRIPTION	BY		
0	12/01/22	90% ZONING	M.M		
1	04/17/23	100% ZONING	M.M		
2	02/07/24	CLIENT REVISION	M.M		
3	02/14/24	PLAN CHECK	M.M		

LICENSURE:

PRELIMINARY:
NOT FOR
CONSTRUCTION

IT IS A VIOLATION OF LAW FOR ANY PERSON UNLESS THEY ARE ACTING UNDER THE DIRECTION OF A LICENSED PROFESSIONAL ENGINEER, TO ALTER THIS DOCUMENT.

SHEET TITLE:

BATTERY SPECIFICATIONS


SHEET NUMBER

BATTERY SPECIFICATIONS

SCALE:
NONE

Form #: SDS 85302

Revised: AG

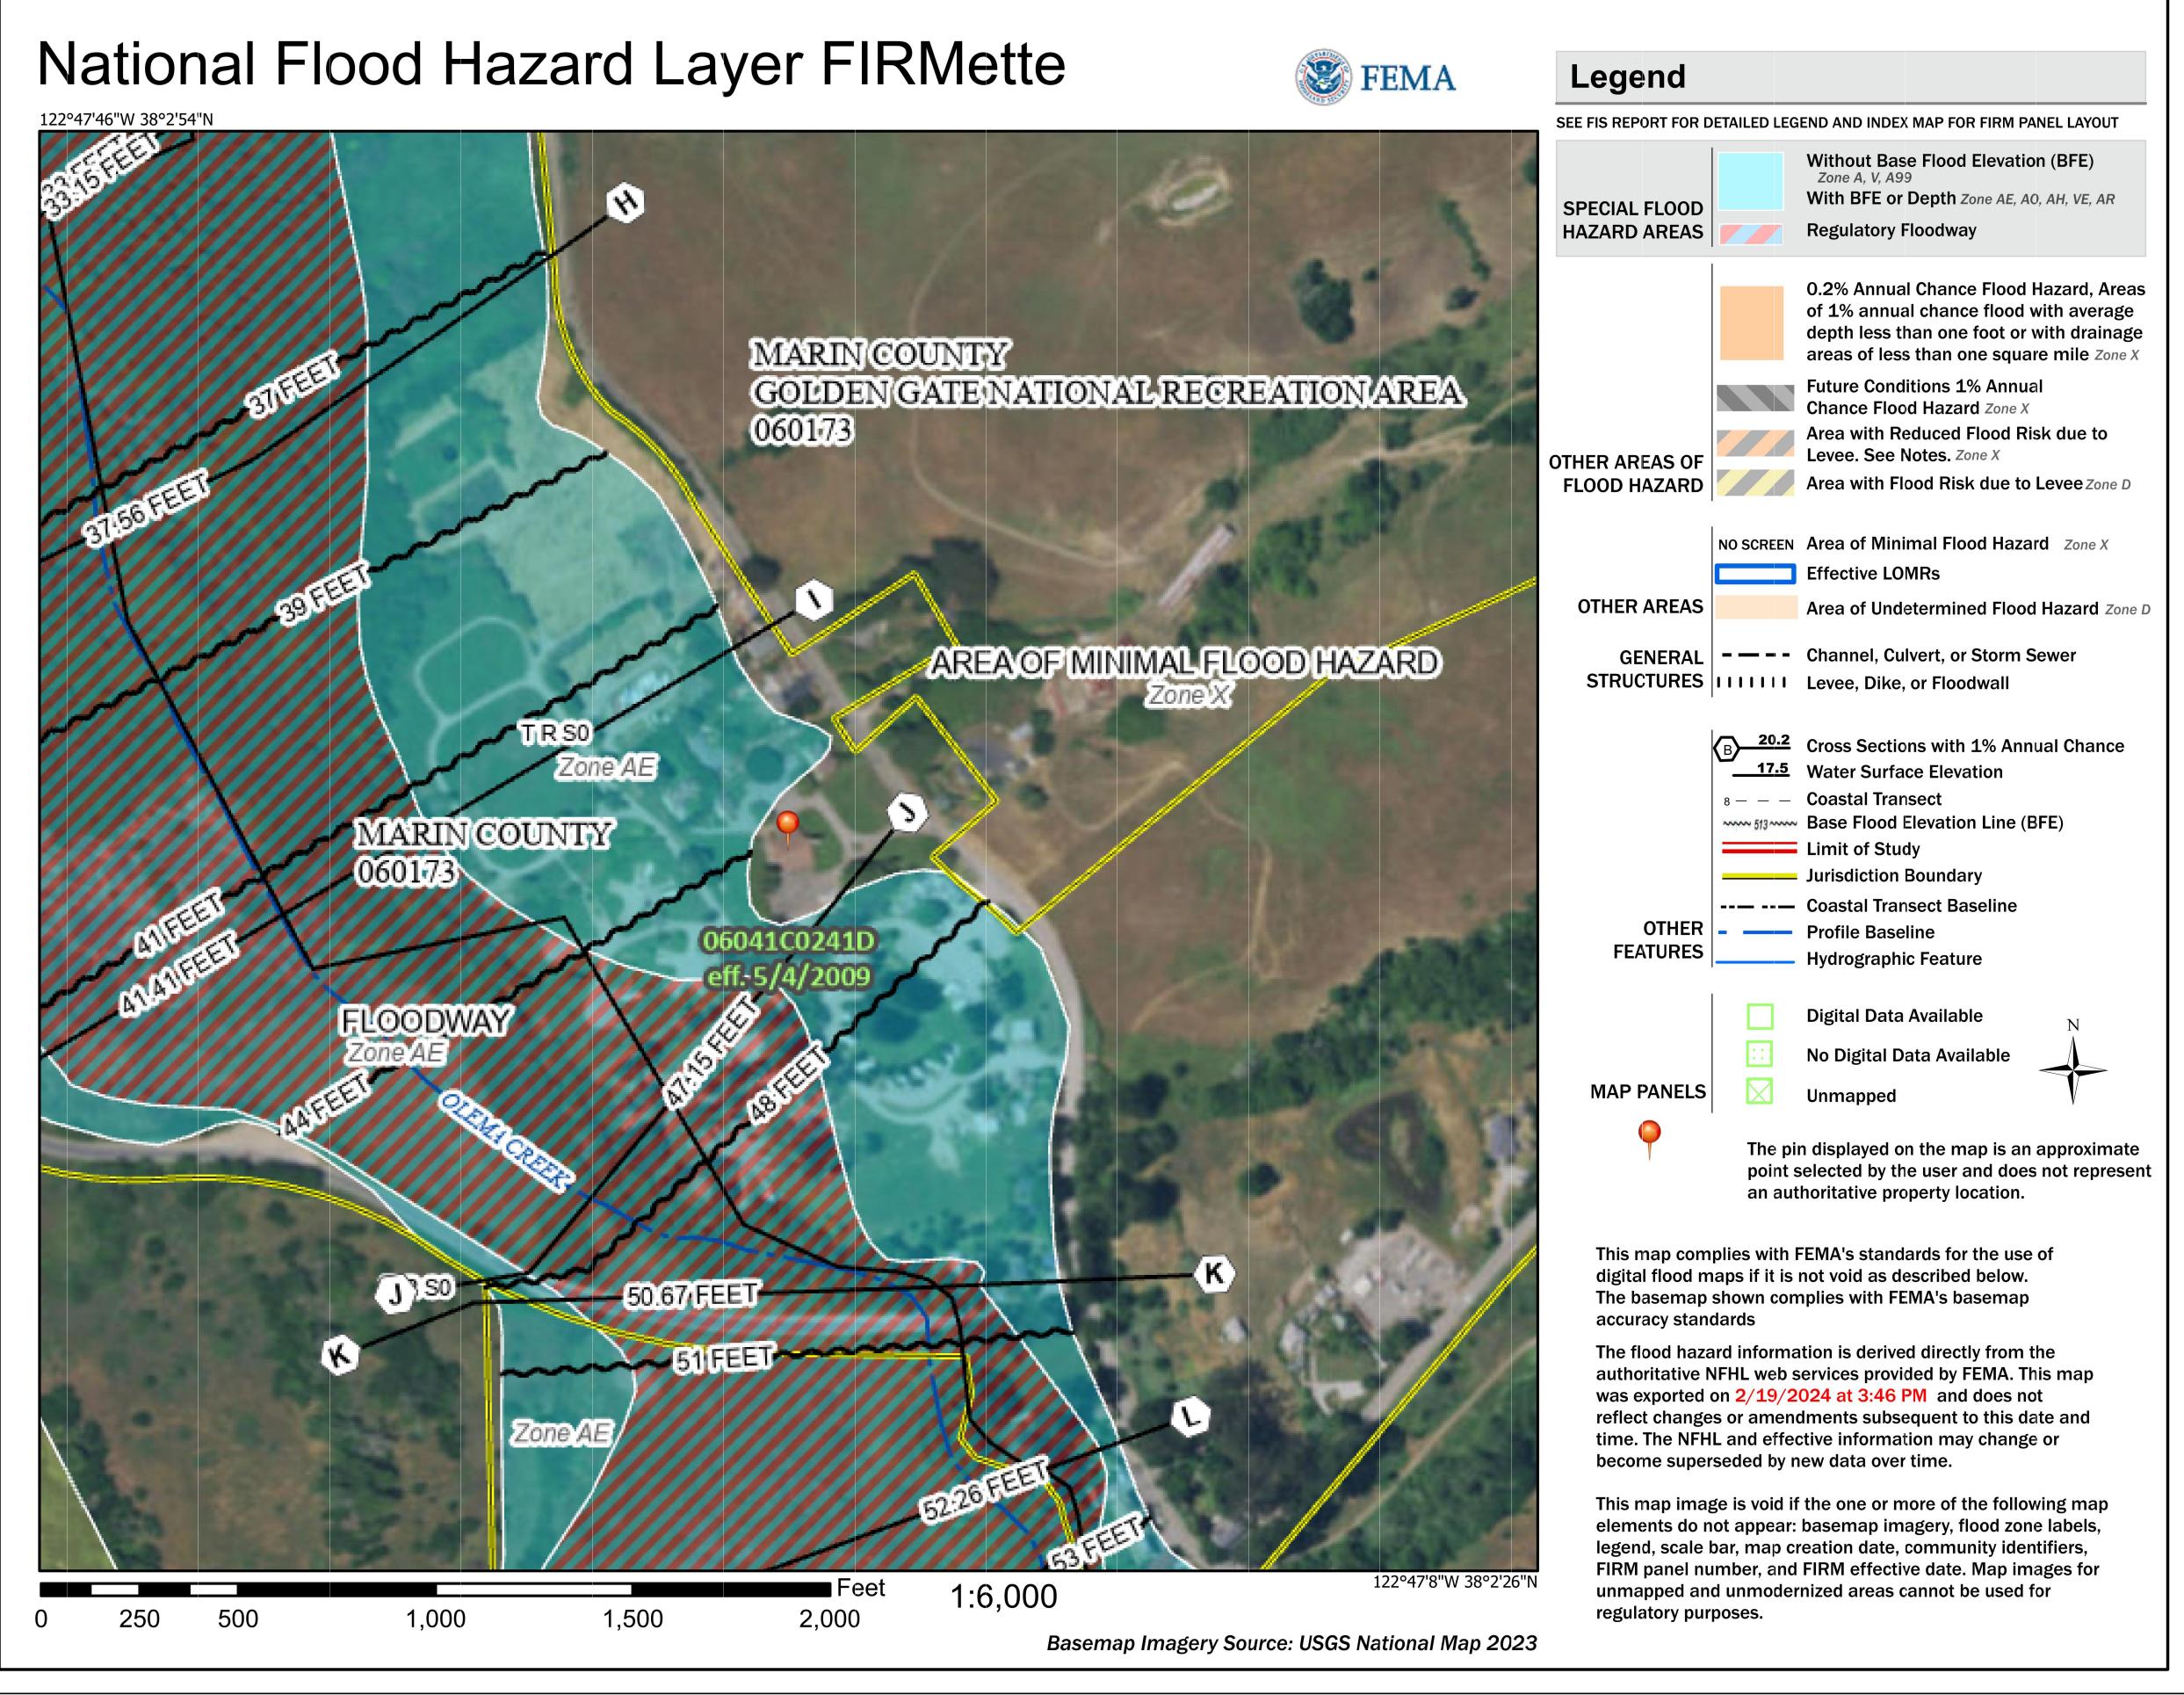

CCL05072 SACRED HEART

10189 SHORELINE HIGHWAY POINT REYES STATION, CA 94956

PREPARED FOR



5001 EXECUTIVE PARKWAY SAN RAMON, CALIFORNIA 94583

VENDO

SPECTRUM A Nextedge Company

4850 WEST OQUENDO ROAD LAS VEGAS, NEVADA 89118 PHONE: (702) 367-7705 FAX: (702) 367-8733

AT&T SITE NO: CCL05072

PROJECT NO: -

DRAWN BY: M. MARASIGAN

CHECKED BY: B. OXBORROW

APPROVED BY: C. WENER

ISSUE STATUS					
REV.	DATE	DESCRIPTION	BY		
0	12/01/22	90% ZONING	M.M		
1	04/17/23	100% ZONING	M.M		
2	02/07/24	CLIENT REVISION	M.M		
3	02/14/24	PLAN CHECK	M.M		

LICENSURE:

PRELIMINARY:
NOT FOR
CONSTRUCTION

IT IS A VIOLATION OF LAW FOR ANY PERSON, UNLESS THEY ARE ACTING UNDER THE DIRECTION OF A LICENSED PROFESSIONAL ENGINEER, TO ALTER THIS DOCUMENT.

SHEET TITLE:


FEMA FLOOD ZONE MAP

SHEET NUMBER

FEMA FLOOD ZONE MAP

SCALE:
NONE

#### arin County Stormwater Pollution Prevention Program **Minimum Control Measures** For Small Construction Projects

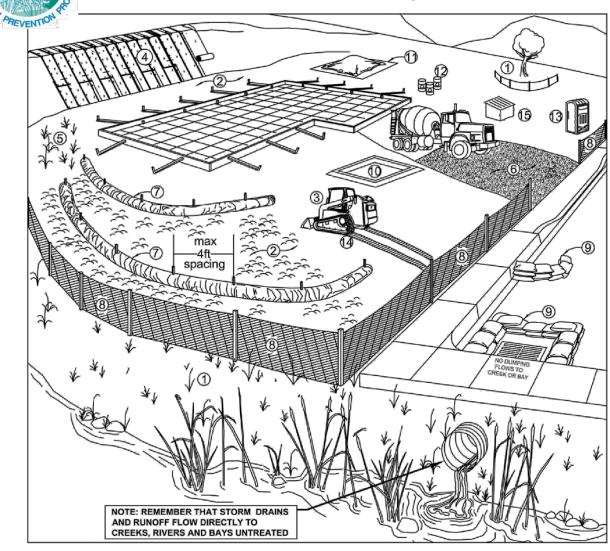


1	Sediment Controls	Good Housekeeping
6.	Tracking Controls	10. Concrete Washout
s 7.	Fiber Rolls	11. Stockpile Management
8.	Silt Fence	12. Hazardous Material Management
9.	Drain Inlet Protection	13. Sanitary Waste Management
NS	Trench Dewatering	14. Equipment and Vehicle Maintenance
	<del>-</del>	15. Litter and Waste Management
	8. 9.	s 7. Fiber Rolls 8. Silt Fence


Note: Select an effective combination of control measures from each category, Erosion Control, Sediment Control, and Good Housekeeping. Control measures shall be continually implemented and maintained throughout the project until activities are complete, disturbed areas are stabilized with permanent erosion controls, and the local agency has signed off on permits that may have been required for the project. Inspect and maintain the control measures before and after rain events, and as required by the local agency or state permit. More detailed information on the BMPs can be found in the related California Stormwater Quality Association (CASQA) and


California Department of Transportation (Caltrans) BMP Factsheets. CASQA factsheets are available by subscription in the California Best Management Practices Handbook Portal: Construction at http://www.casqa.org. Caltrans factsheets are available in the Construction Site BMP Manual March 2003 at http://www.dot.ca.gov/hq/construc/stormwater/manuals.htm. Visit www.mcstoppp.org for more information on construction site management and Erosion and Sediment Control Plans.

MCSTOPPP Trench Dewatering BMPs

If you require materials in alternative formats, please contact: 415-473-4381 voice/TTY or disabilityaccess@co.marin.ca.us

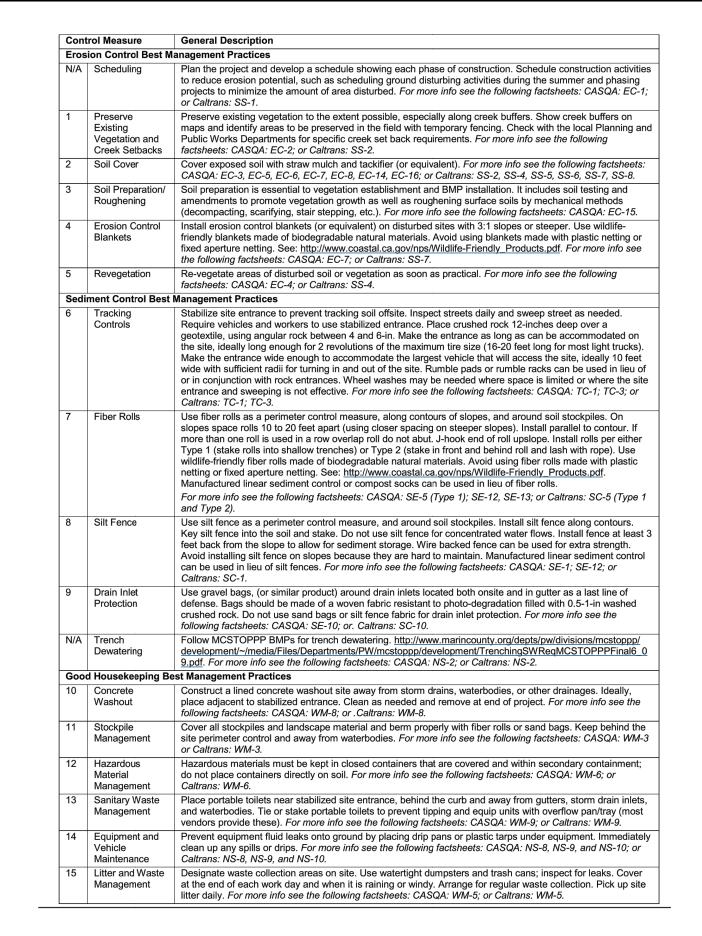

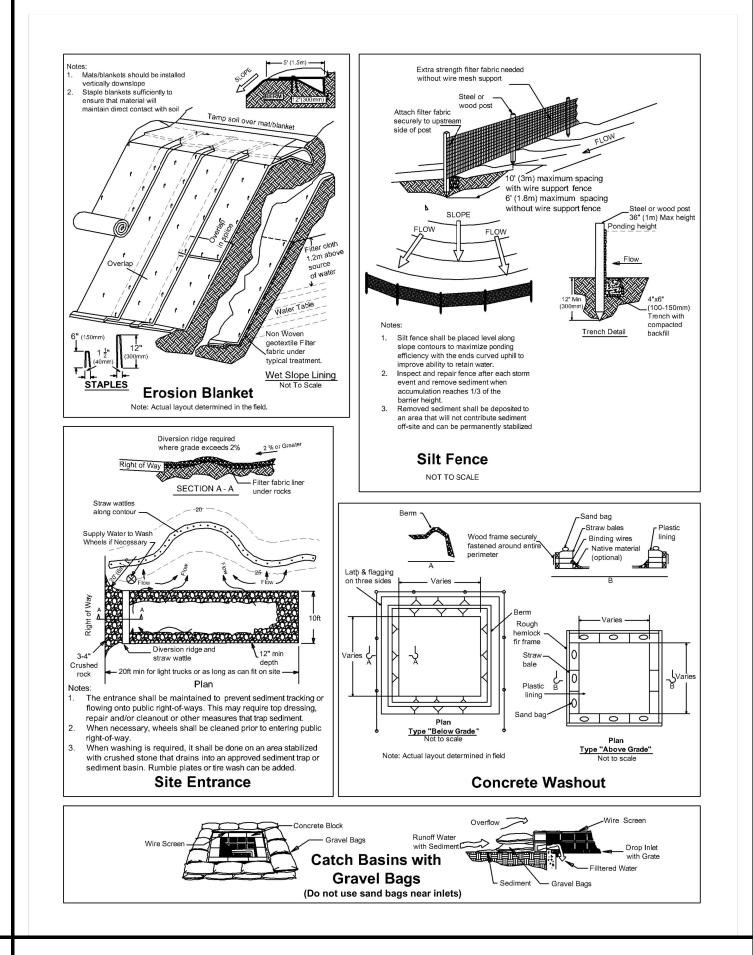

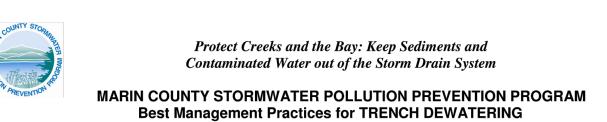

### **Requirements for Dewatering Discharges from Minor Street Excavations**

- The Federal Clean Water Act, the California Water Code, and local ordinances **prohibit** non-stormwater discharges to the storm drain system.
- Non-stormwater discharges include water that is actually or potentially contaminated with any pollutant, including, but not limited to, sewage, grease, drilling mud and oil.
- Uncontaminated pumped groundwater or accumulated rainwater may be discharged to the storm drain system but must be managed to minimize sediment reaching storm drains and ensure downstream creeks, wetlands, and the Bay are not polluted.
- The storm drain system includes streets, gutters, storm drain inlets, ditches, creeks, and wetlands.

IF YOUR SITE OR PROJECT REQUIRES DEWATERING, CONTACT YOUR LOCAL STORMWATER COORDINATOR BEFORE DISCHARGING WATER TO THE STORM DRAIN SYSTEM. CONTACT INFORMATION ON THE REVERSE PAGE.

As necessary, local municipal staff will determine whether flows from dewatering a particular excavation may be discharged to the storm drain system and what measures must be taken to reduce sediment in the discharge.

Depending on circumstances, holders of encroachment or building permits may be directed to use one or more of the following measures:

- Avoid the discharge. Disperse pumped water to a level dirt or landscaped area to allow infiltration or use for dust control. Be sure to prevent damage to
- Build a sediment trap (temporary basin formed by excavation or earthen embankment across a low drainage area to detain sediment-laden runoff and allow sediment to settle out before discharging).
- Use a mobile weir tank, dewatering tank, or sand filter (follow vendor instructions).

or hauled to a suitable disposal site.

• At minimum, use a gravity bag filter (dewatering bag) or similar filtration device (follow vendor instructions).

Odors, discoloration, or an oily sheen can indicate contaminants in the water. Dewatering discharges containing contaminants may need to be captured and treated

Some dewatering discharges require a National Pollutant Discharge Elimination System (NPDES) permit from the San Francisco Bay Regional Water Quality Control Board (RWQCB). For more information, call the RWQCB or visit their website: Phone: 510-622-2300

Web: <a href="http://www.waterboards.ca.gov/sanfranciscobay/npdes-gen-permit.shtml">http://www.waterboards.ca.gov/sanfranciscobay/npdes-gen-permit.shtml</a>



# Protect Creeks and the Bay: Keep Sediments and

### **Marin County Local Municipal Stormwater Coordinators (415 Prefix)**

Town of San Anselmo 289-4111 or 289-4100 ext. 106 258-4616 or 258-2600 (M-Th)

**Town of Corte Madera** City of San Rafael 927-5069 or 927-5057 (M-Th) 485-3355

City of Belvedere 435-3838 (M-Th)

**Town of Ross** 453-8287 or 453-1453 ext. 163

458-0291 or 453-1584 (M-Th) City of Novato 899-8246

**Town of Fairfax** 

City of Mill Valley 388-4033 ext. 116

City of Sausalito

**County of Marin** 

499-3748 or 499-6528

**Town of Tiburon** 

435-7354 or 435-7399

City of Larkspur

927-5028 or 927-5017 (M-Th)



California State Water Resources Control Board, Municipal Phase II Stormwater NPDES Permit  $CASQA, \textit{Dewatering Operations:} \ \underline{\textit{http://www.cabmphandbooks.com/Documents/Construction/NS-2.pdf}$ Marin County Stormwater Pollution Prevention Program, http://www.mcstoppp.org/acrobat/AP2010\_20050520%20.pdf Caltrans, Construction Site Best Management Practices Manual, Dewatering Operations NS-2 (<u>http://www.dot.ca.gov/hq/construc/stormwater/NS02Update.doc</u>)

> **Marin County Stormwater Pollution Prevention Program** P.O. Box 4186 • San Rafael, CA 94913 • 415-499-6528 www.mcstoppp.org

If you require materials in alternative formats, please contact: 415-473-4381 voice/TTY or disabilityaccess@co.marin.ca.us

PROJECT INFORMATION:

### CCL05072 SACRED HEART

10189 SHORELINE HIGHWAY POINT REYES STATION, CA 94956

PREPARED FOR



5001 EXECUTIVE PARKWAY SAN RAMON, CALIFORNIA 94583

**VENDOR:** 



SPECTRUM SERVICES, LLC 4850 WEST OQUENDO ROAD LAS VEGAS, NEVADA 89118 PHONE: (702) 367-7705 FAX: (702) 367-8733

AT&T SITE NO: CCL05072

PROJECT NO: -

DRAWN BY: M. MARASIGAN

CHECKED BY: B. OXBORROW

APPROVED BY: C. WENER

ISSUE STATUS					
0	12/01/22	90% ZONING	M.M		
1	04/17/23	100% ZONING	M.M		
2	02/07/24	CLIENT REVISION	M.M		
3	02/14/24	PLAN CHECK	M.M		

LICENSURE:

PRELIMINARY: NOT FOR CONSTRUCTION


IT IS A VIOLATION OF LAW FOR ANY PERSON, UNLESS THEY ARE ACTING UNDER THE DIRECTION OF A LICENSED PROFESSIONAL ENGINEER, TO ALTER THIS DOCUMENT.


SHEET TITLE:

**EROSION & SEDIMENT** CONTROL

SHEET NUMBER

SCALE: NONE **EROSION & SEDIMENT CONTROL** 

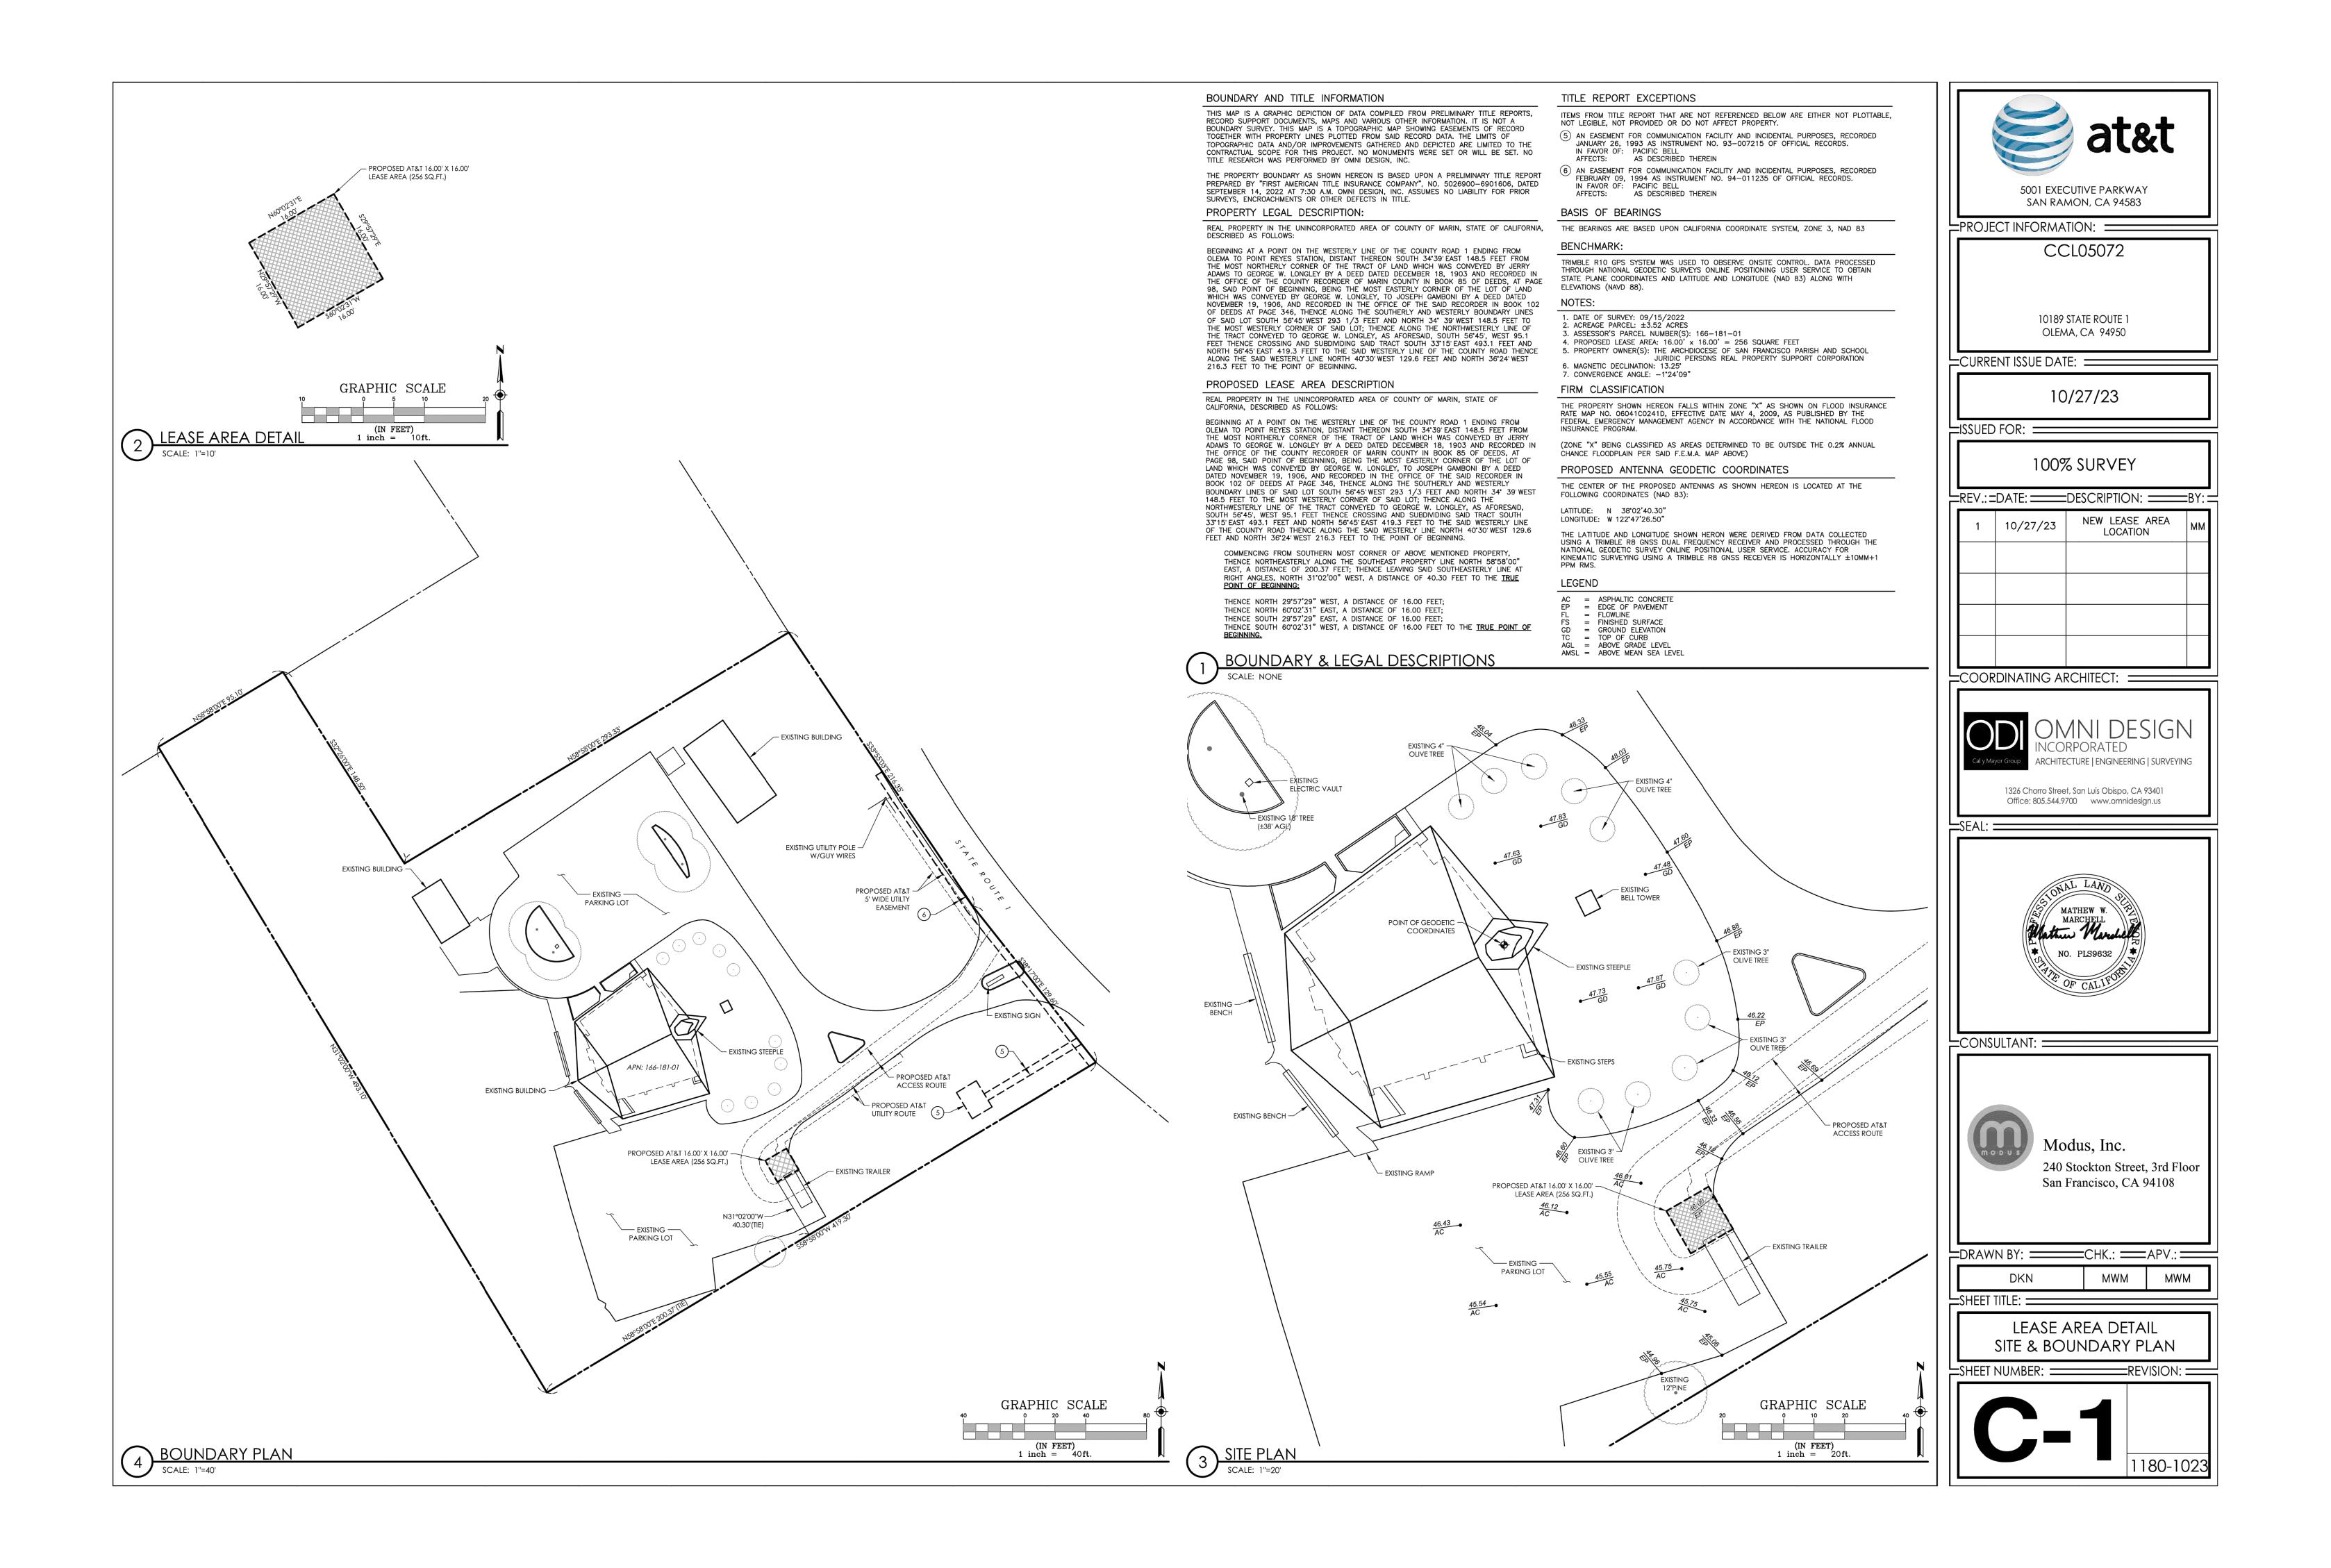

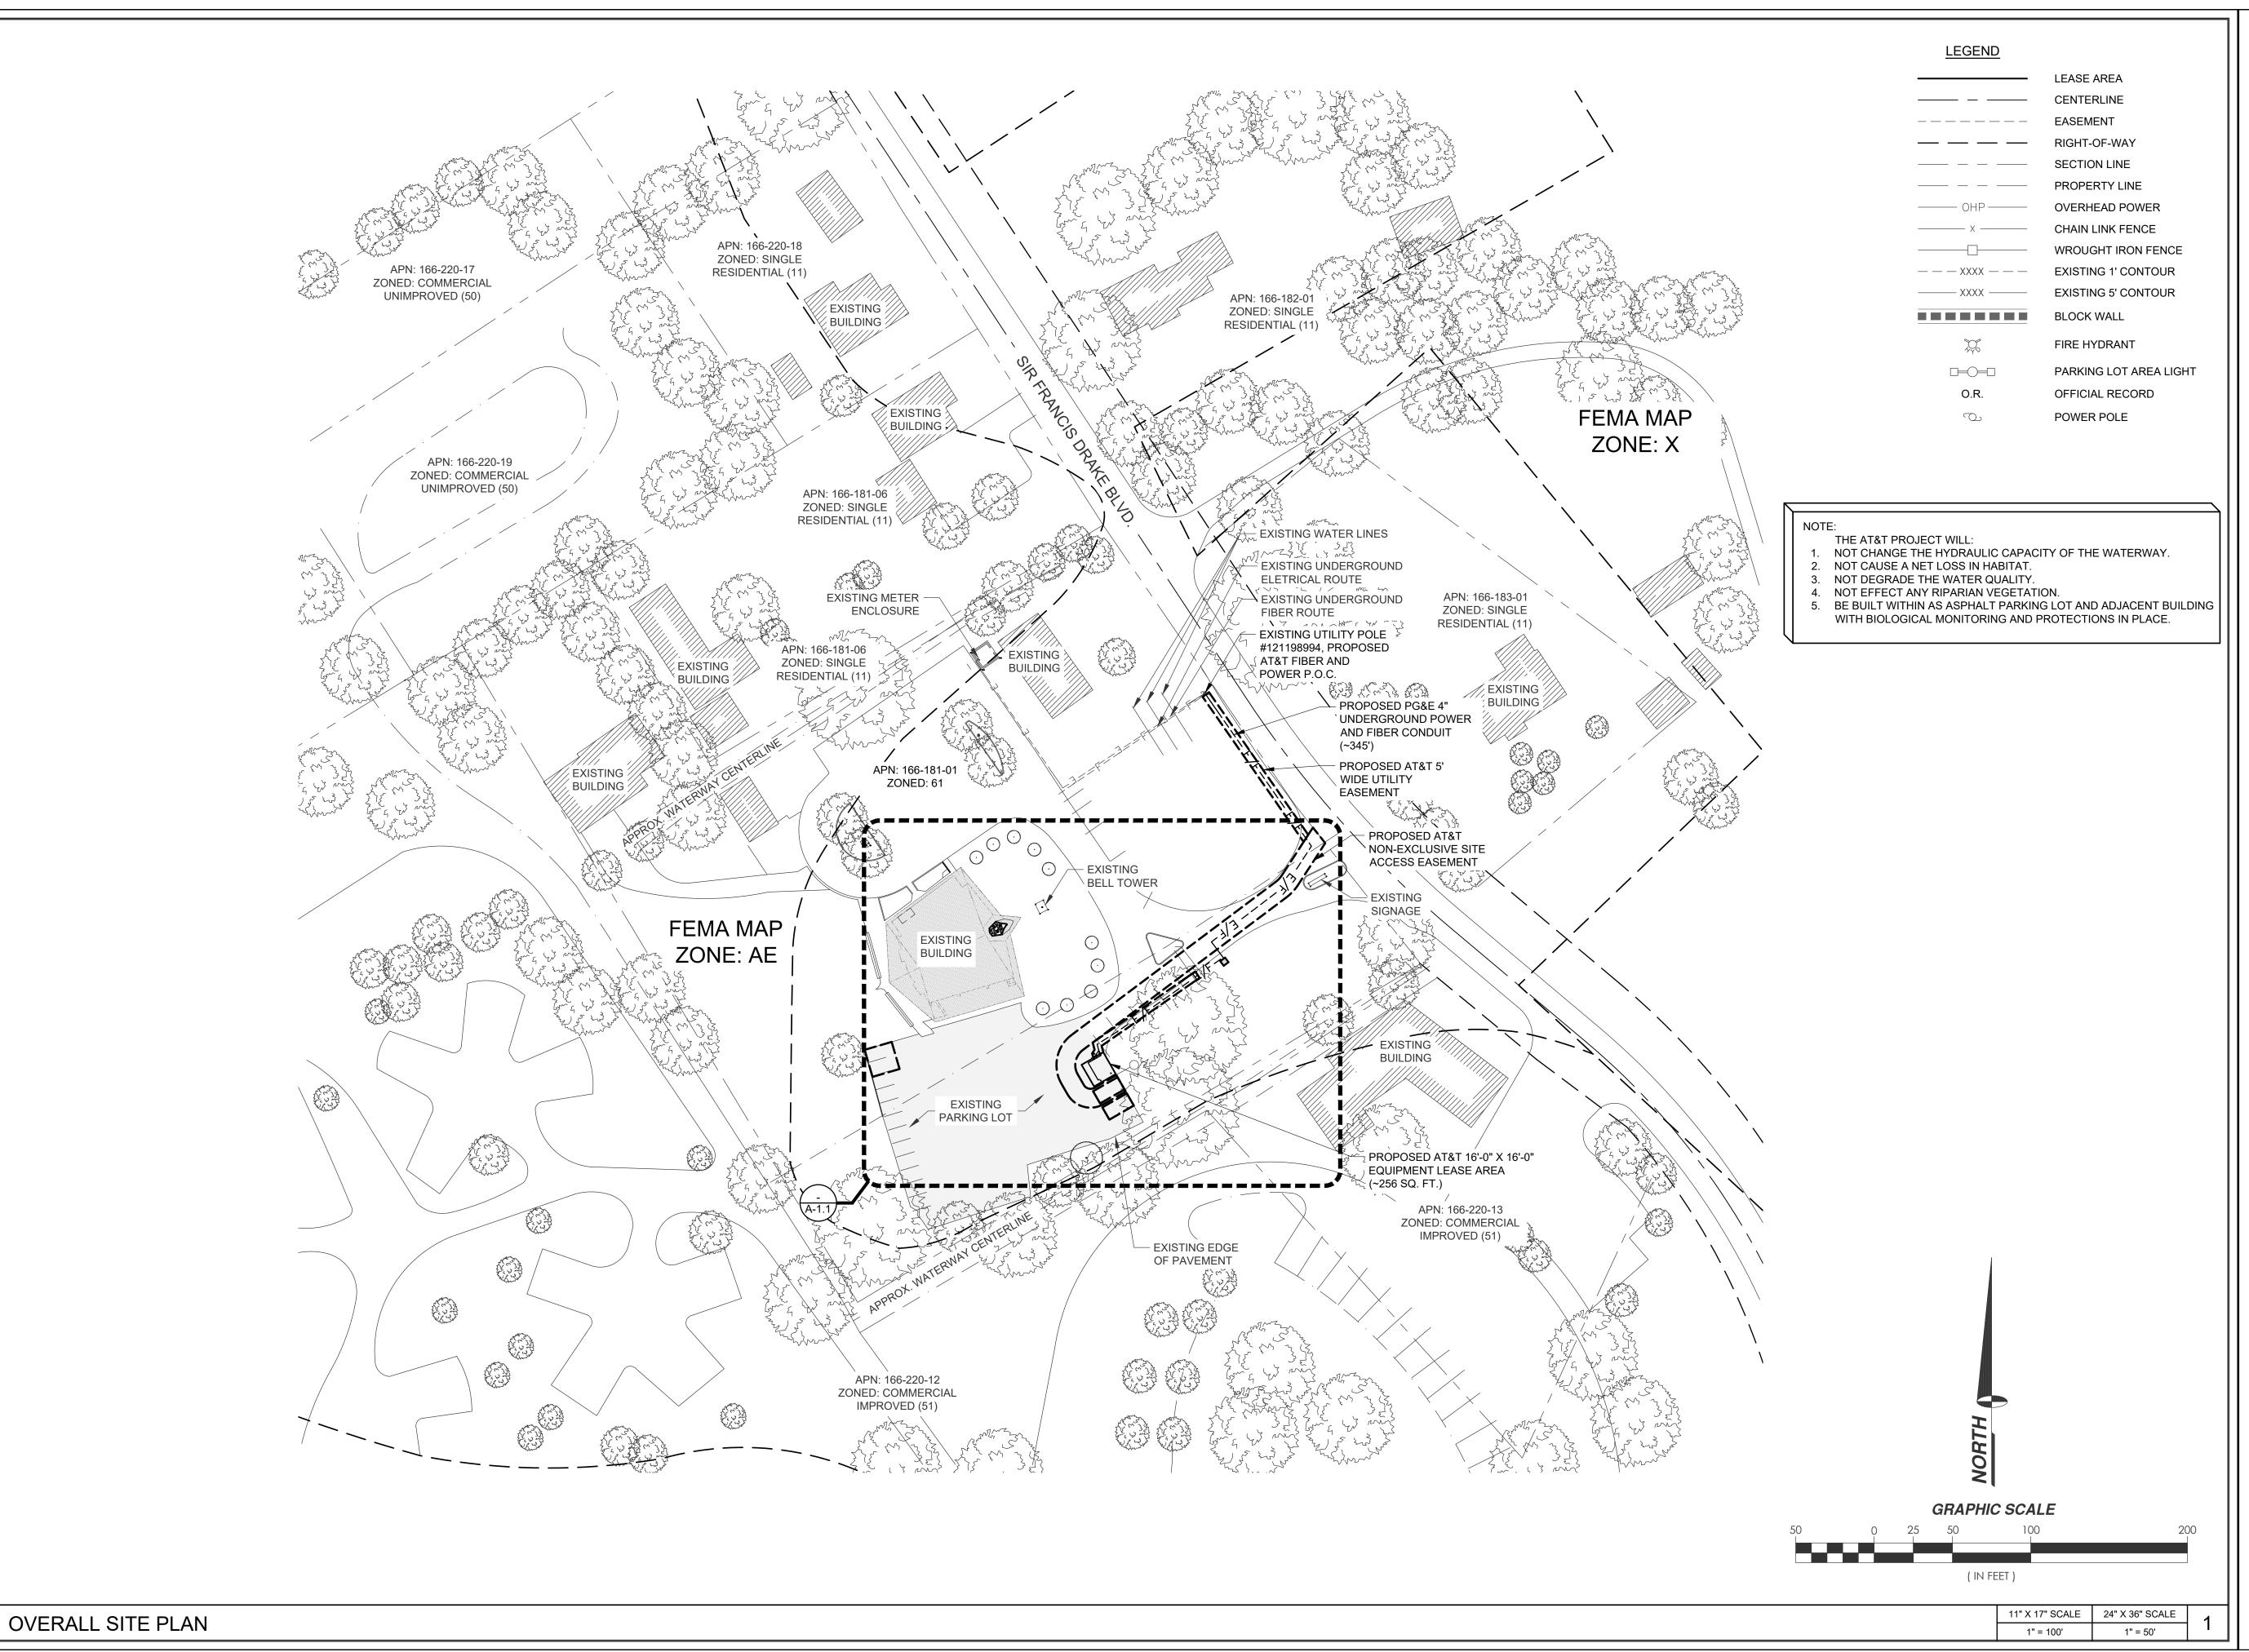

# CCL05072 SACRED HEART

10189 SHORELINE HIGHWAY POINT REYES STATION, CA 94956

PREPARED FOR



5001 EXECUTIVE PARKWAY SAN RAMON, CALIFORNIA 94583

VENDOR:



SPECTRUM SERVICES, LLC. 4850 WEST OQUENDO ROAD LAS VEGAS, NEVADA 89118 PHONE: (702) 367-7705 FAX: (702) 367-8733

AT&T SITE NO: CCL05072

PROJECT NO: -

INOULOT NO.

DRAWN BY: M. MARASIGAN

CHECKED BY: B. OXBORROW

APPROVED BY: C. WENER

	ISSUE STATUS						
F	REV.	DATE	DESCRIPTION	BY			
	0	12/01/22	90% ZONING	M.M.			
	1	04/17/23	100% ZONING	M.M.			
	2	02/07/24	CLIENT REVISION	M.M.			
	3	02/14/24	PLAN CHECK	M.M.			


### LICENSURE:

PRELIMINARY:
NOT FOR
CONSTRUCTION

IT IS A VIOLATION OF LAW FOR ANY PERSON, UNLESS THEY ARE ACTING UNDER THE DIRECTION OF A LICENSED PROFESSIONAL ENGINEER, TO ALTER THIS DOCUMENT.

SHEET TITLE:

OVERALL SITE PLAN

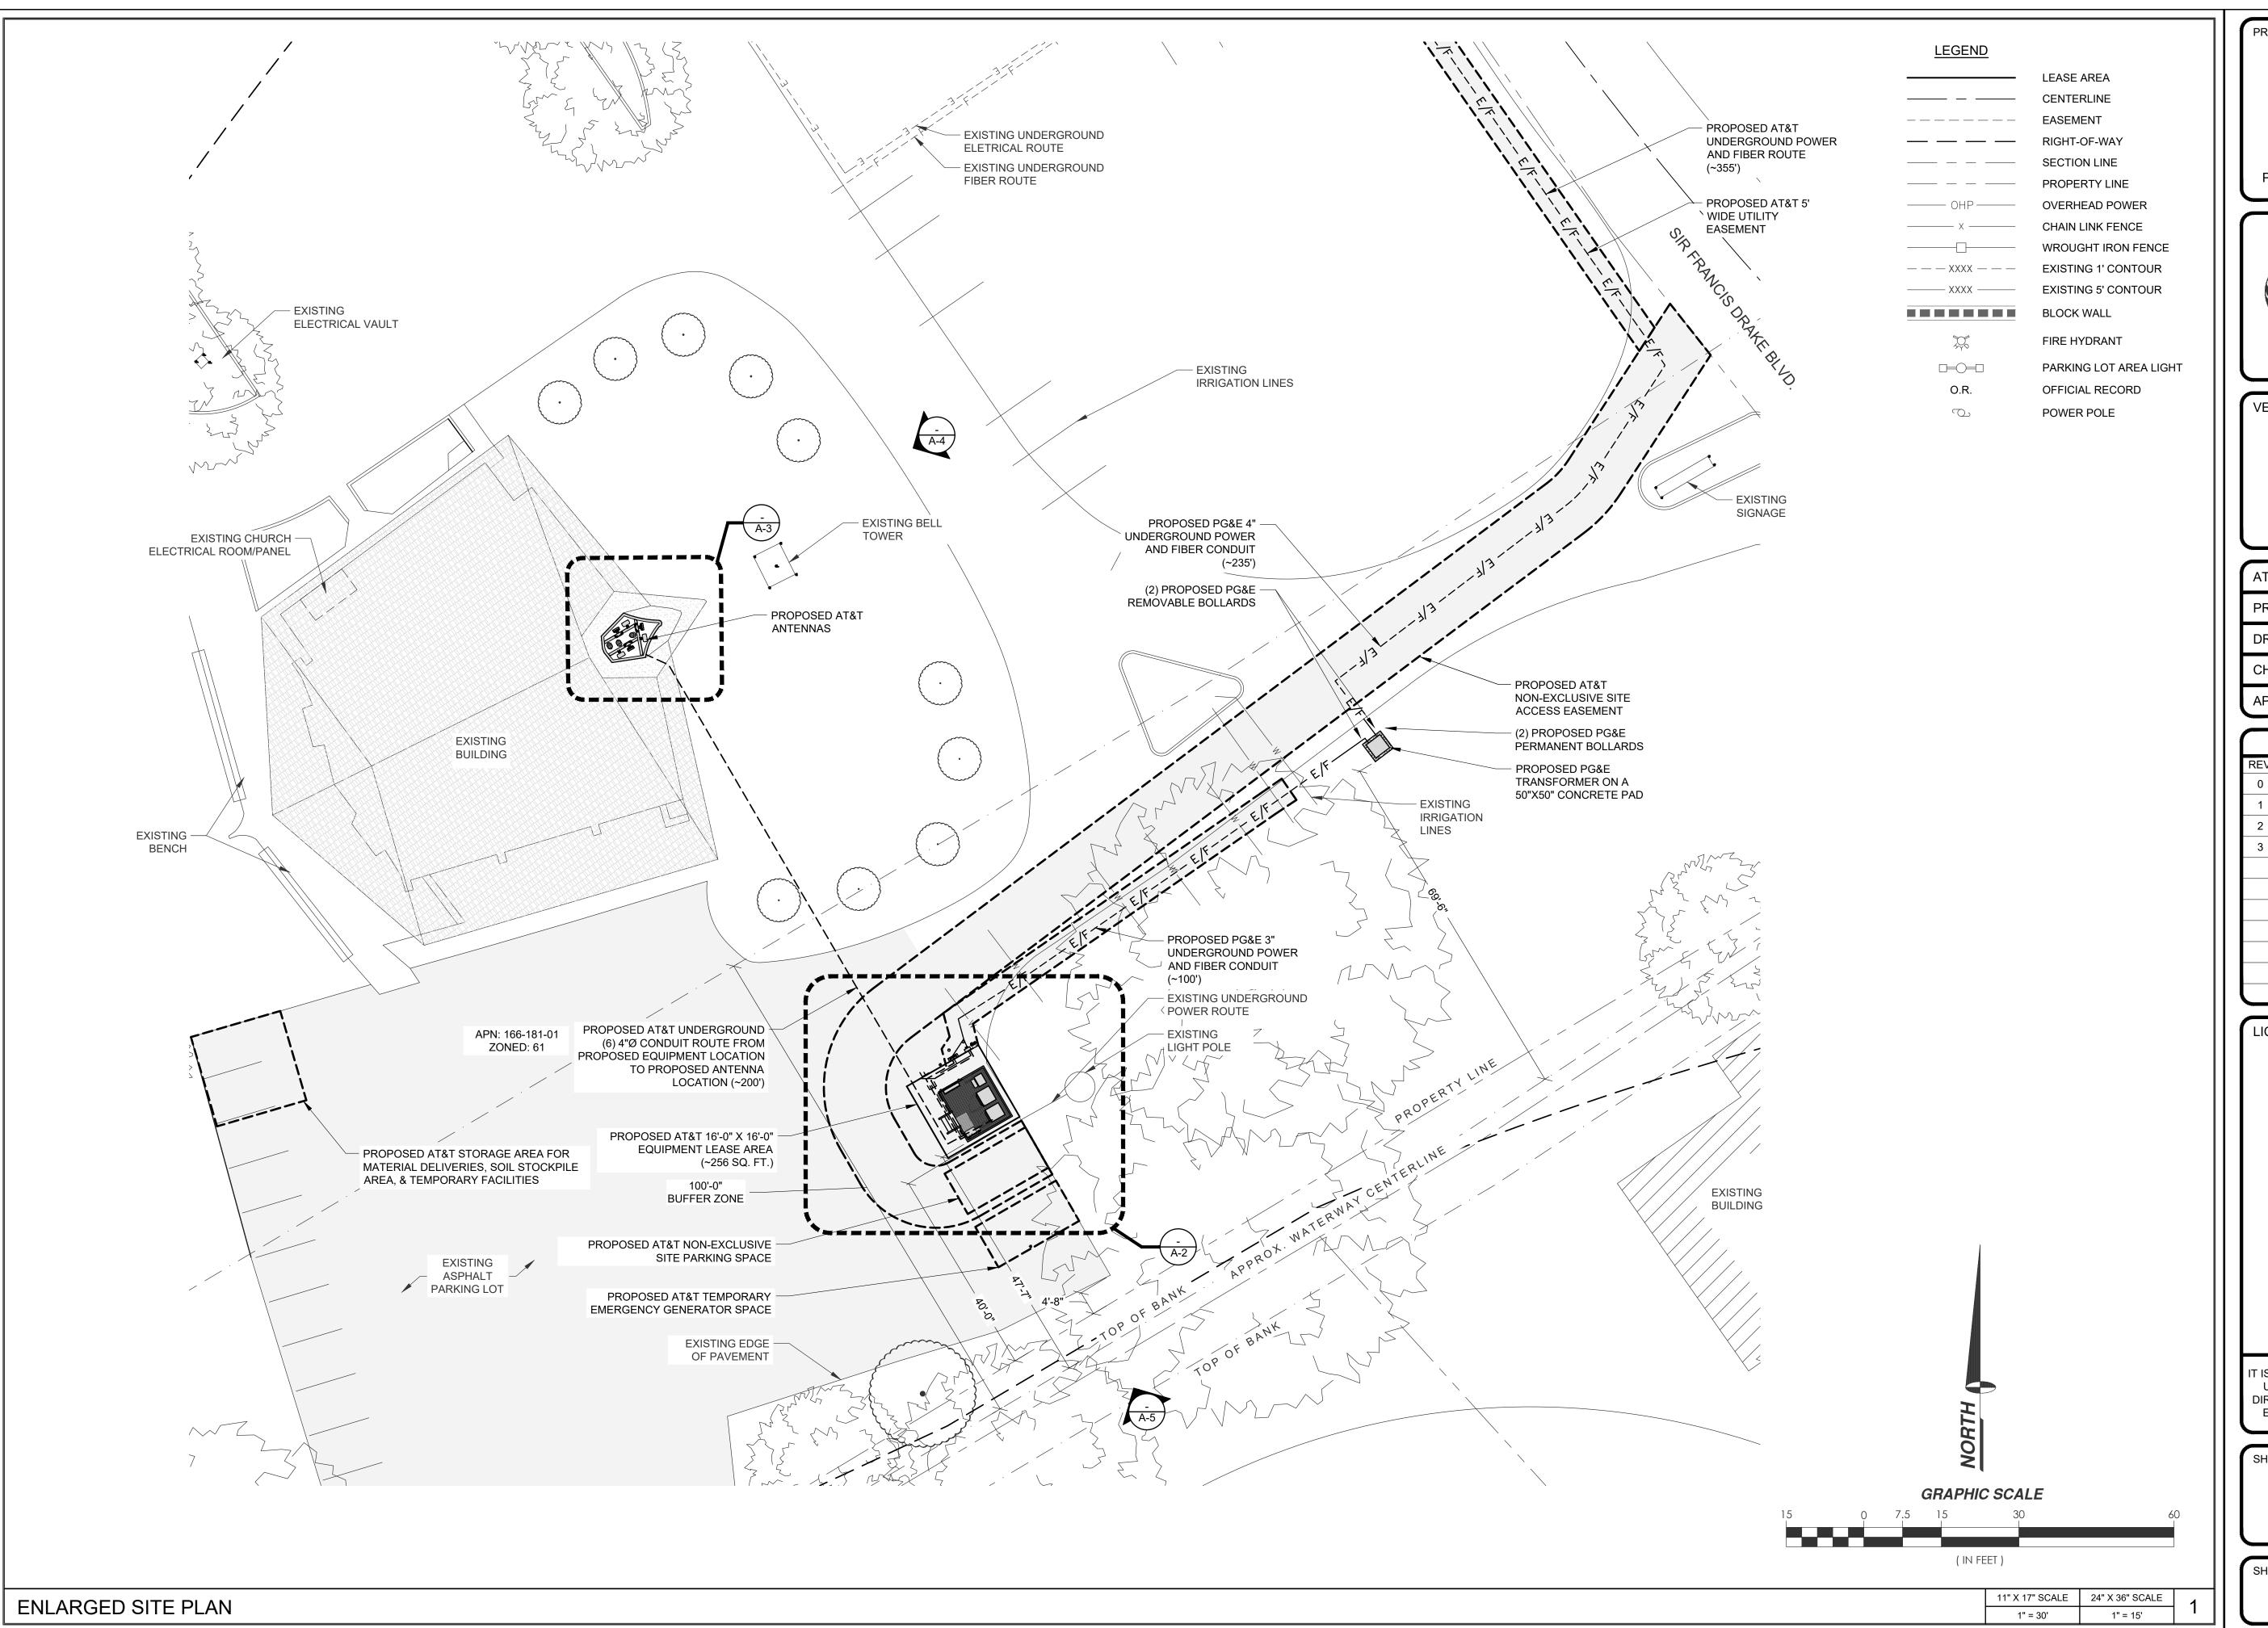

# CCL05072 SACRED HEART

10189 SHORELINE HIGHWAY POINT REYES STATION, CA 94956

PREPARED FOR



5001 EXECUTIVE PARKWAY SAN RAMON, CALIFORNIA 94583

VENDOR:



SPECTRUM SERVICES, LLC. 4850 WEST OQUENDO ROAD LAS VEGAS, NEVADA 89118 PHONE: (702) 367-7705 FAX: (702) 367-8733

AT&T SITE NO: CCL05072

PROJECT NO: -

DRAWN BY: M. MARASIGAN

CHECKED BY: B. OXBORROW

APPROVED BY: C. WENER

ISSUE STATUS					
REV.	DATE	DESCRIPTION	BY		
0	12/01/22	90% ZONING	M.M		
1	04/17/23	100% ZONING	M.M		
2	02/07/24	CLIENT REVISION	M.M		
3	02/14/24	PLAN CHECK	M.M		


### LICENSURE:

PRELIMINARY:
NOT FOR
CONSTRUCTION

IT IS A VIOLATION OF LAW FOR ANY PERSON, UNLESS THEY ARE ACTING UNDER THE DIRECTION OF A LICENSED PROFESSIONAL ENGINEER, TO ALTER THIS DOCUMENT.

SHEET TITLE:

ENLARGED SITE PLAN

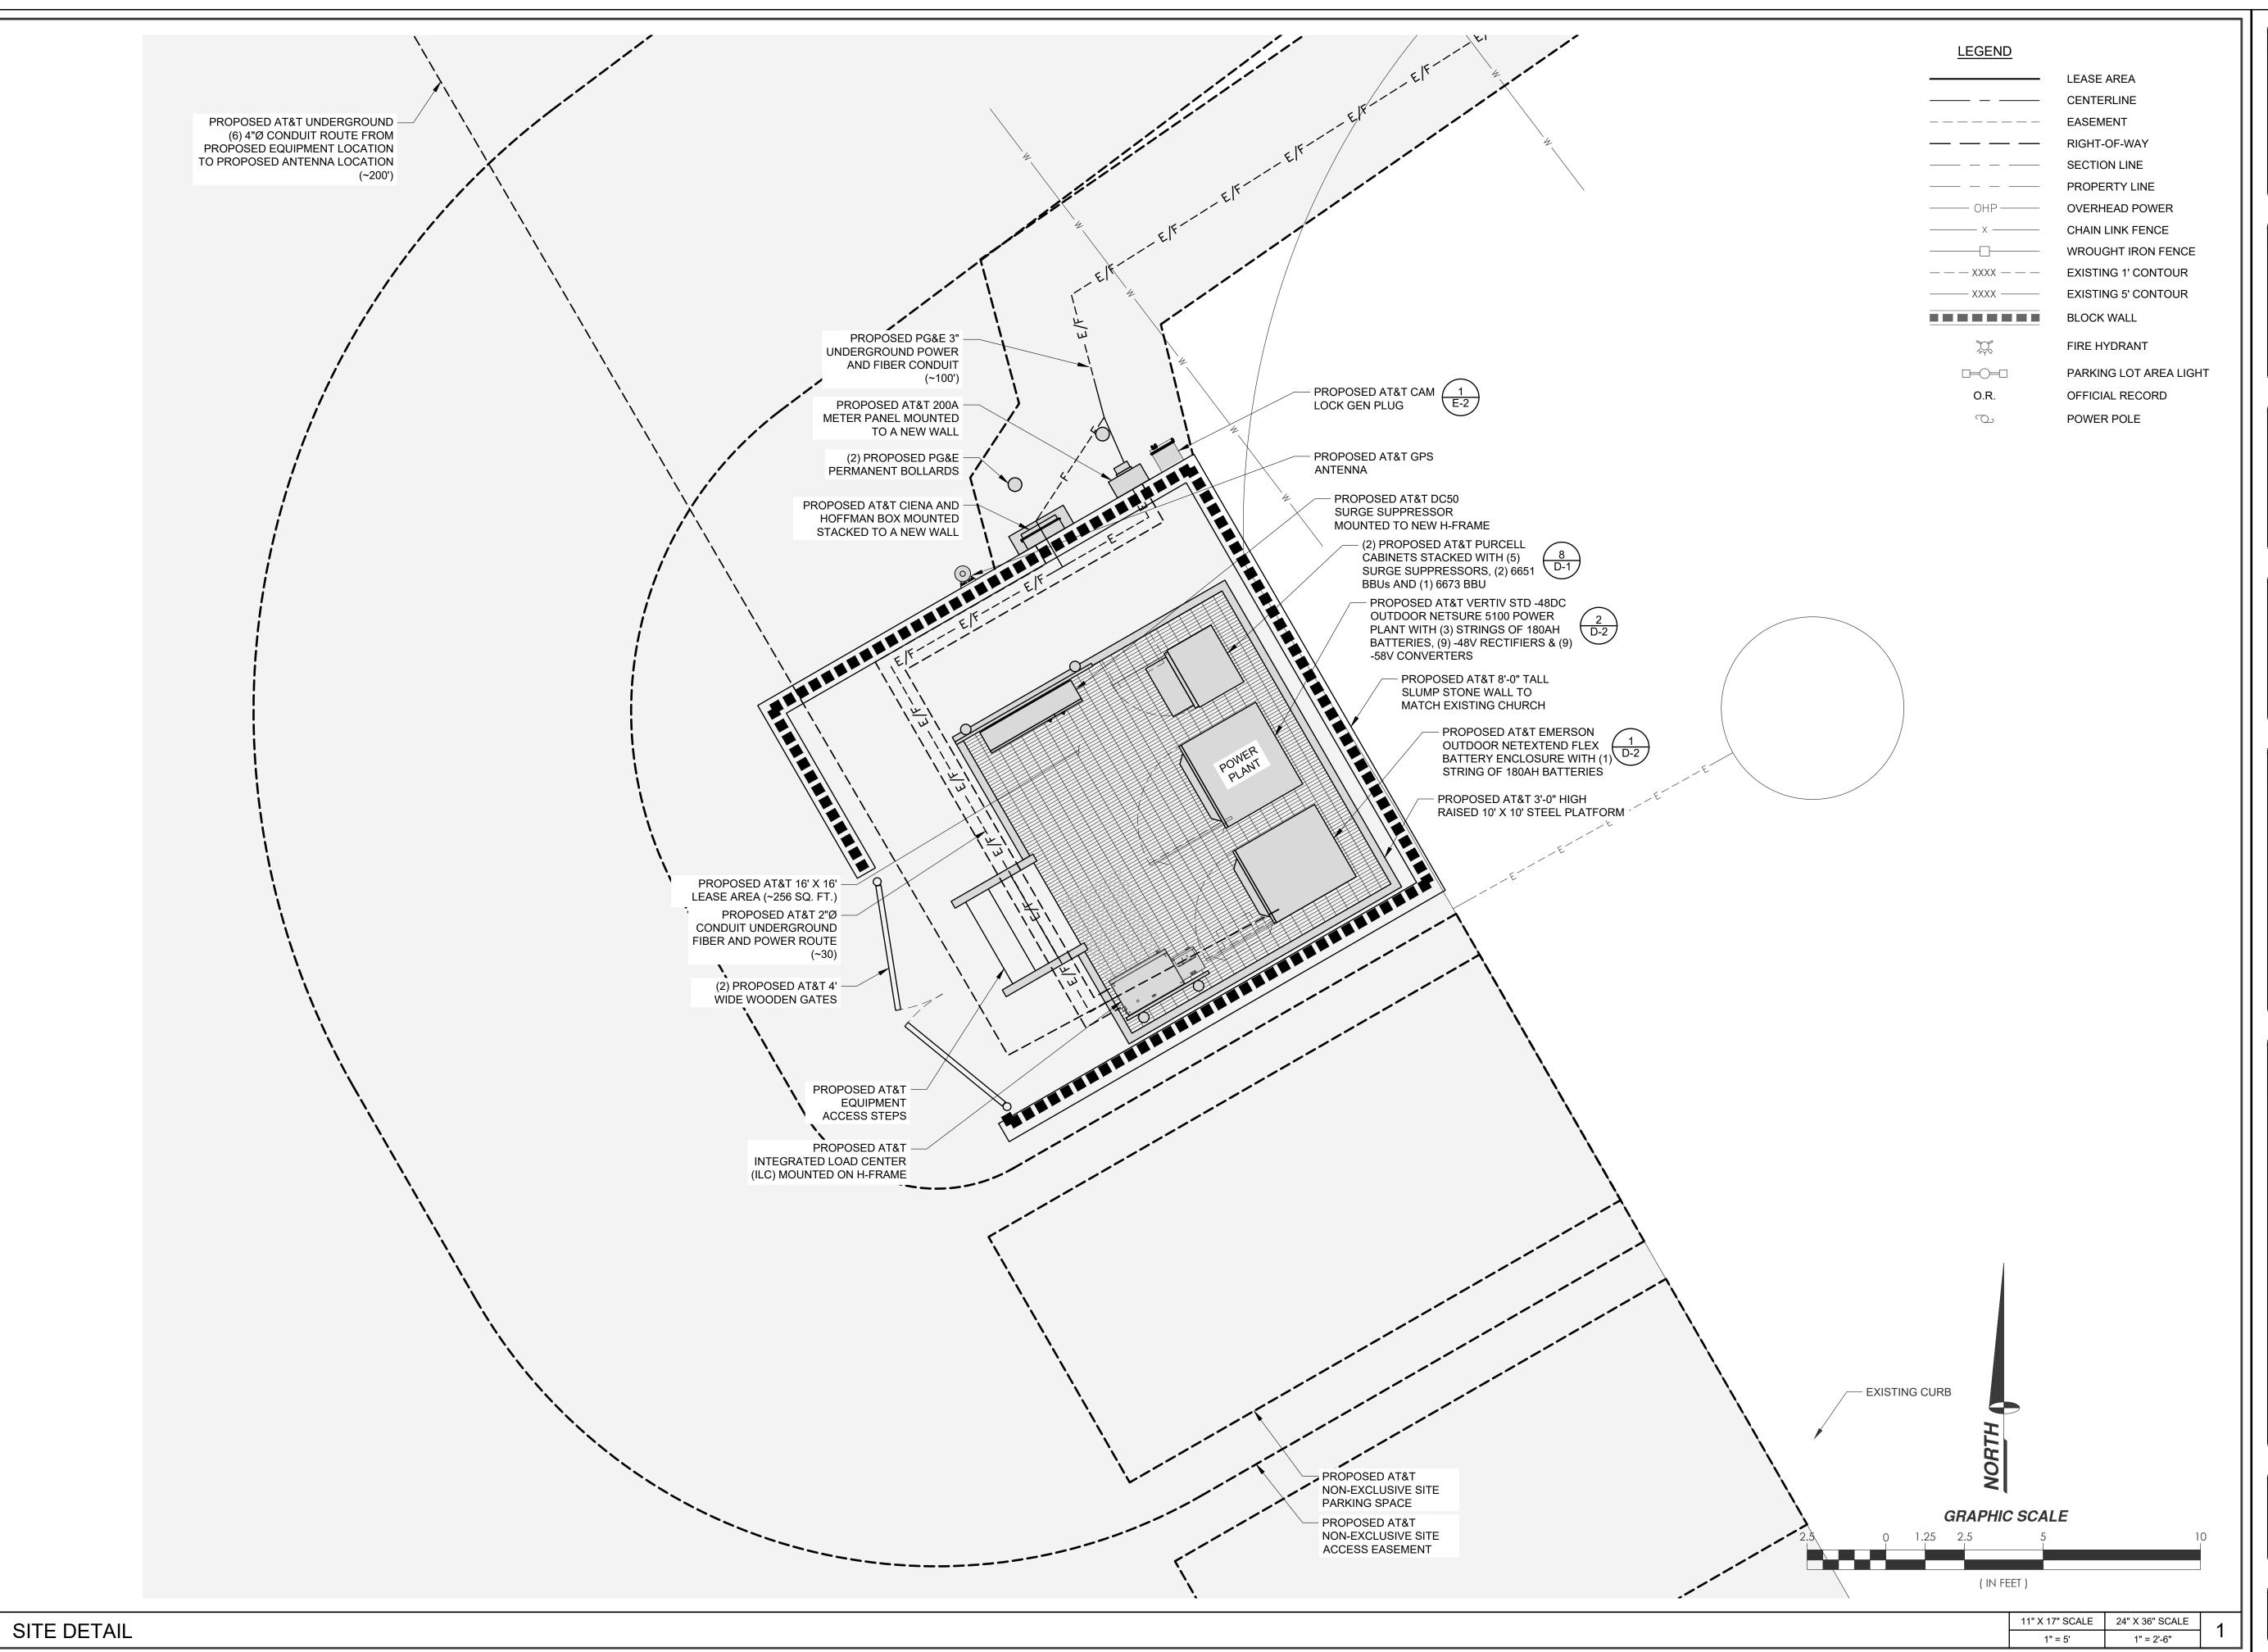

# CCL05072 SACRED HEART

10189 SHORELINE HIGHWAY POINT REYES STATION, CA 94956

PREPARED FOR



5001 EXECUTIVE PARKWAY SAN RAMON, CALIFORNIA 94583

VENDOR:



SPECTRUM SERVICES, LLC. 4850 WEST OQUENDO ROAD LAS VEGAS, NEVADA 89118 PHONE: (702) 367-7705 FAX: (702) 367-8733

AT&T SITE NO: CCL05072

PROJECT NO: -

CHECKED BY: B. OXBORROW

DRAWN BY: M. MARASIGAN

APPROVED BY: C. WENER

		ISSI	JE STATUS	
	REV.	DATE	DESCRIPTION	BY
	0	12/01/22	90% ZONING	M.M.
Ш	1	04/17/23	100% ZONING	M.M.
Ш	2	02/07/24	CLIENT REVISION	M.M.
	3	02/14/24	PLAN CHECK	M.M.
Ш				
Ш				
				_


LICENSURE:

PRELIMINARY:
NOT FOR
CONSTRUCTION

IT IS A VIOLATION OF LAW FOR ANY PERSON, UNLESS THEY ARE ACTING UNDER THE DIRECTION OF A LICENSED PROFESSIONAL ENGINEER, TO ALTER THIS DOCUMENT.

SHEET TITLE:

SITE DETAIL

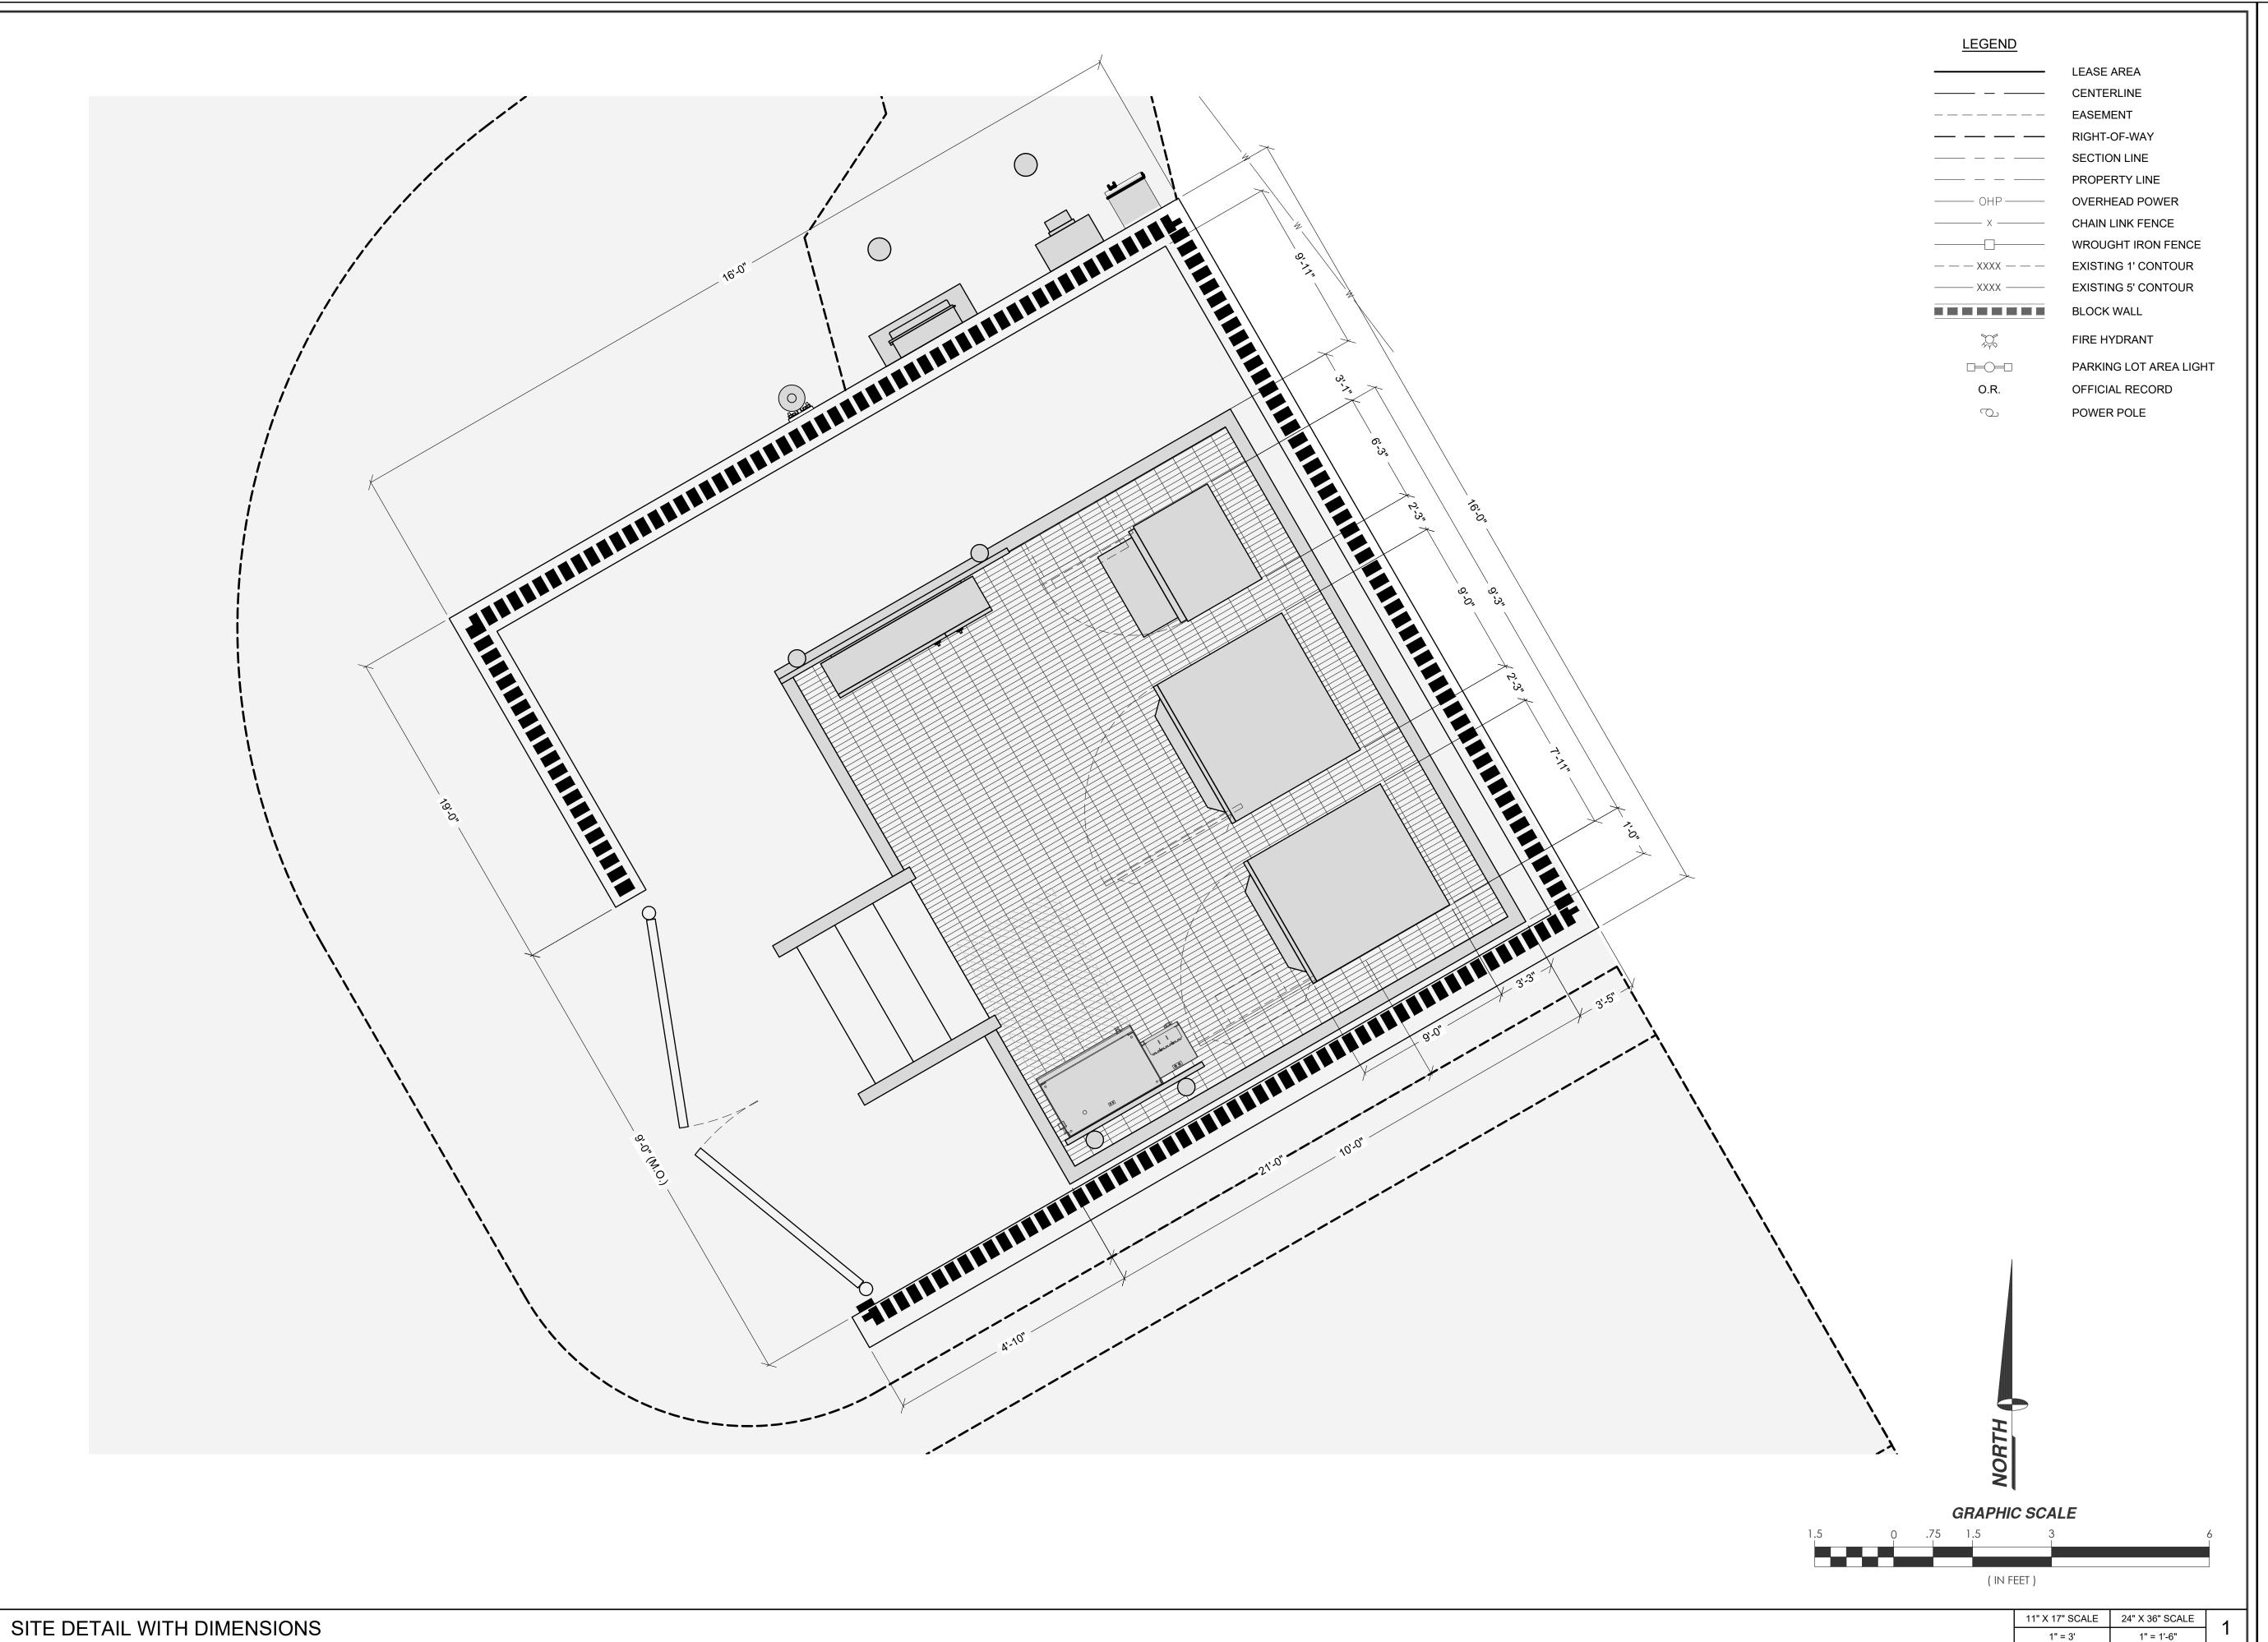

# CCL05072 SACRED HEART

10189 SHORELINE HIGHWAY POINT REYES STATION, CA 94956

PREPARED FOR



5001 EXECUTIVE PARKWAY SAN RAMON, CALIFORNIA 94583

/ENDOR:



SPECTRUM SERVICES, LLC. 4850 WEST OQUENDO ROAD LAS VEGAS, NEVADA 89118 PHONE: (702) 367-7705 FAX: (702) 367-8733

AT&T SITE NO: CCL05072

PROJECT NO: -

DRAWN BY: M. MARASIGAN

CHECKED BY: B. OXBORROW

APPROVED BY: C. WENER

1							
	ISSUE STATUS						
	REV.	DATE	DESCRIPTION	BY			
	0	12/01/22	90% ZONING	M.M.			
	1	04/17/23	100% ZONING	M.M.			
	2	02/07/24	CLIENT REVISION	M.M.			
	3	02/14/24	PLAN CHECK	M.M.			

LICENSURE:

PRELIMINARY:
NOT FOR
CONSTRUCTION


IT IS A VIOLATION OF LAW FOR ANY PERSON, UNLESS THEY ARE ACTING UNDER THE DIRECTION OF A LICENSED PROFESSIONAL ENGINEER, TO ALTER THIS DOCUMENT.

SHEET TITLE:

SITE DETAIL WITH DIMENSIONS

	ANTENNA AND EQUIPMENT SCHEDULE							
SEC	SECTOR ANTENNA # (DIMENSION)		CENTERLINE	AZIMUTH	RRH	CABLE TYPE	HYBRID TYPE	CABLE LENGTH
ΙΑ	A1	FUTURE ERICSSON - AIR6472 B77G/B77M (36.4" X 16.1" X 7.5")	76'-0"	80°	INTEGRATED	(40) FIRED	(1) 9X18	
АГРНА	A2	QUINTEL - QD6616-4 (72" X 22" X 9.6")	69'-0"	80°	(1) RADIO 4490 B5/B12 (1) RADIO 4890 B25/B66 (1) RADIO 4478 B14	(18) FIBER JUMPERS	HYBRID CABLE	180'
ТА	B1	FUTURE ERICSSON - AIR6472 B77G/B77M (36.4" X 16.1" X 7.5")	76'-0"	330°	INTEGRATED	(18) FIBER	BER (1) 9X18	4001
BETA	B2	QUINTEL - QD6616-4 (72" X 22" X 9.6")	69'-0"	330°	(1) RADIO 4490 B5/B12 (1) RADIO 4890 B25/B66 (1) RADIO 4478 B14	JUMPERS	HYBRID CABLE	180'
<sub>Б</sub> АММА	C1	FUTURE ERICSSON - AIR6472 B77G/B77M (36.4" X 16.1" X 7.5")	76'-0"	150°	INTEGRATED	(10)	(1) 9X18 HYBRID 18 CABLE	180'
GAN	C2	QUINTEL - QD6616-4 (72" X 22" X 9.6")	69'-0"	150°	(1) RADIO 4490 B5/B12 (1) RADIO 4890 B25/B66 (1) RADIO 4478 B14	JUMPERS		

PROPOSED EQUIPMENT SCHEDULE

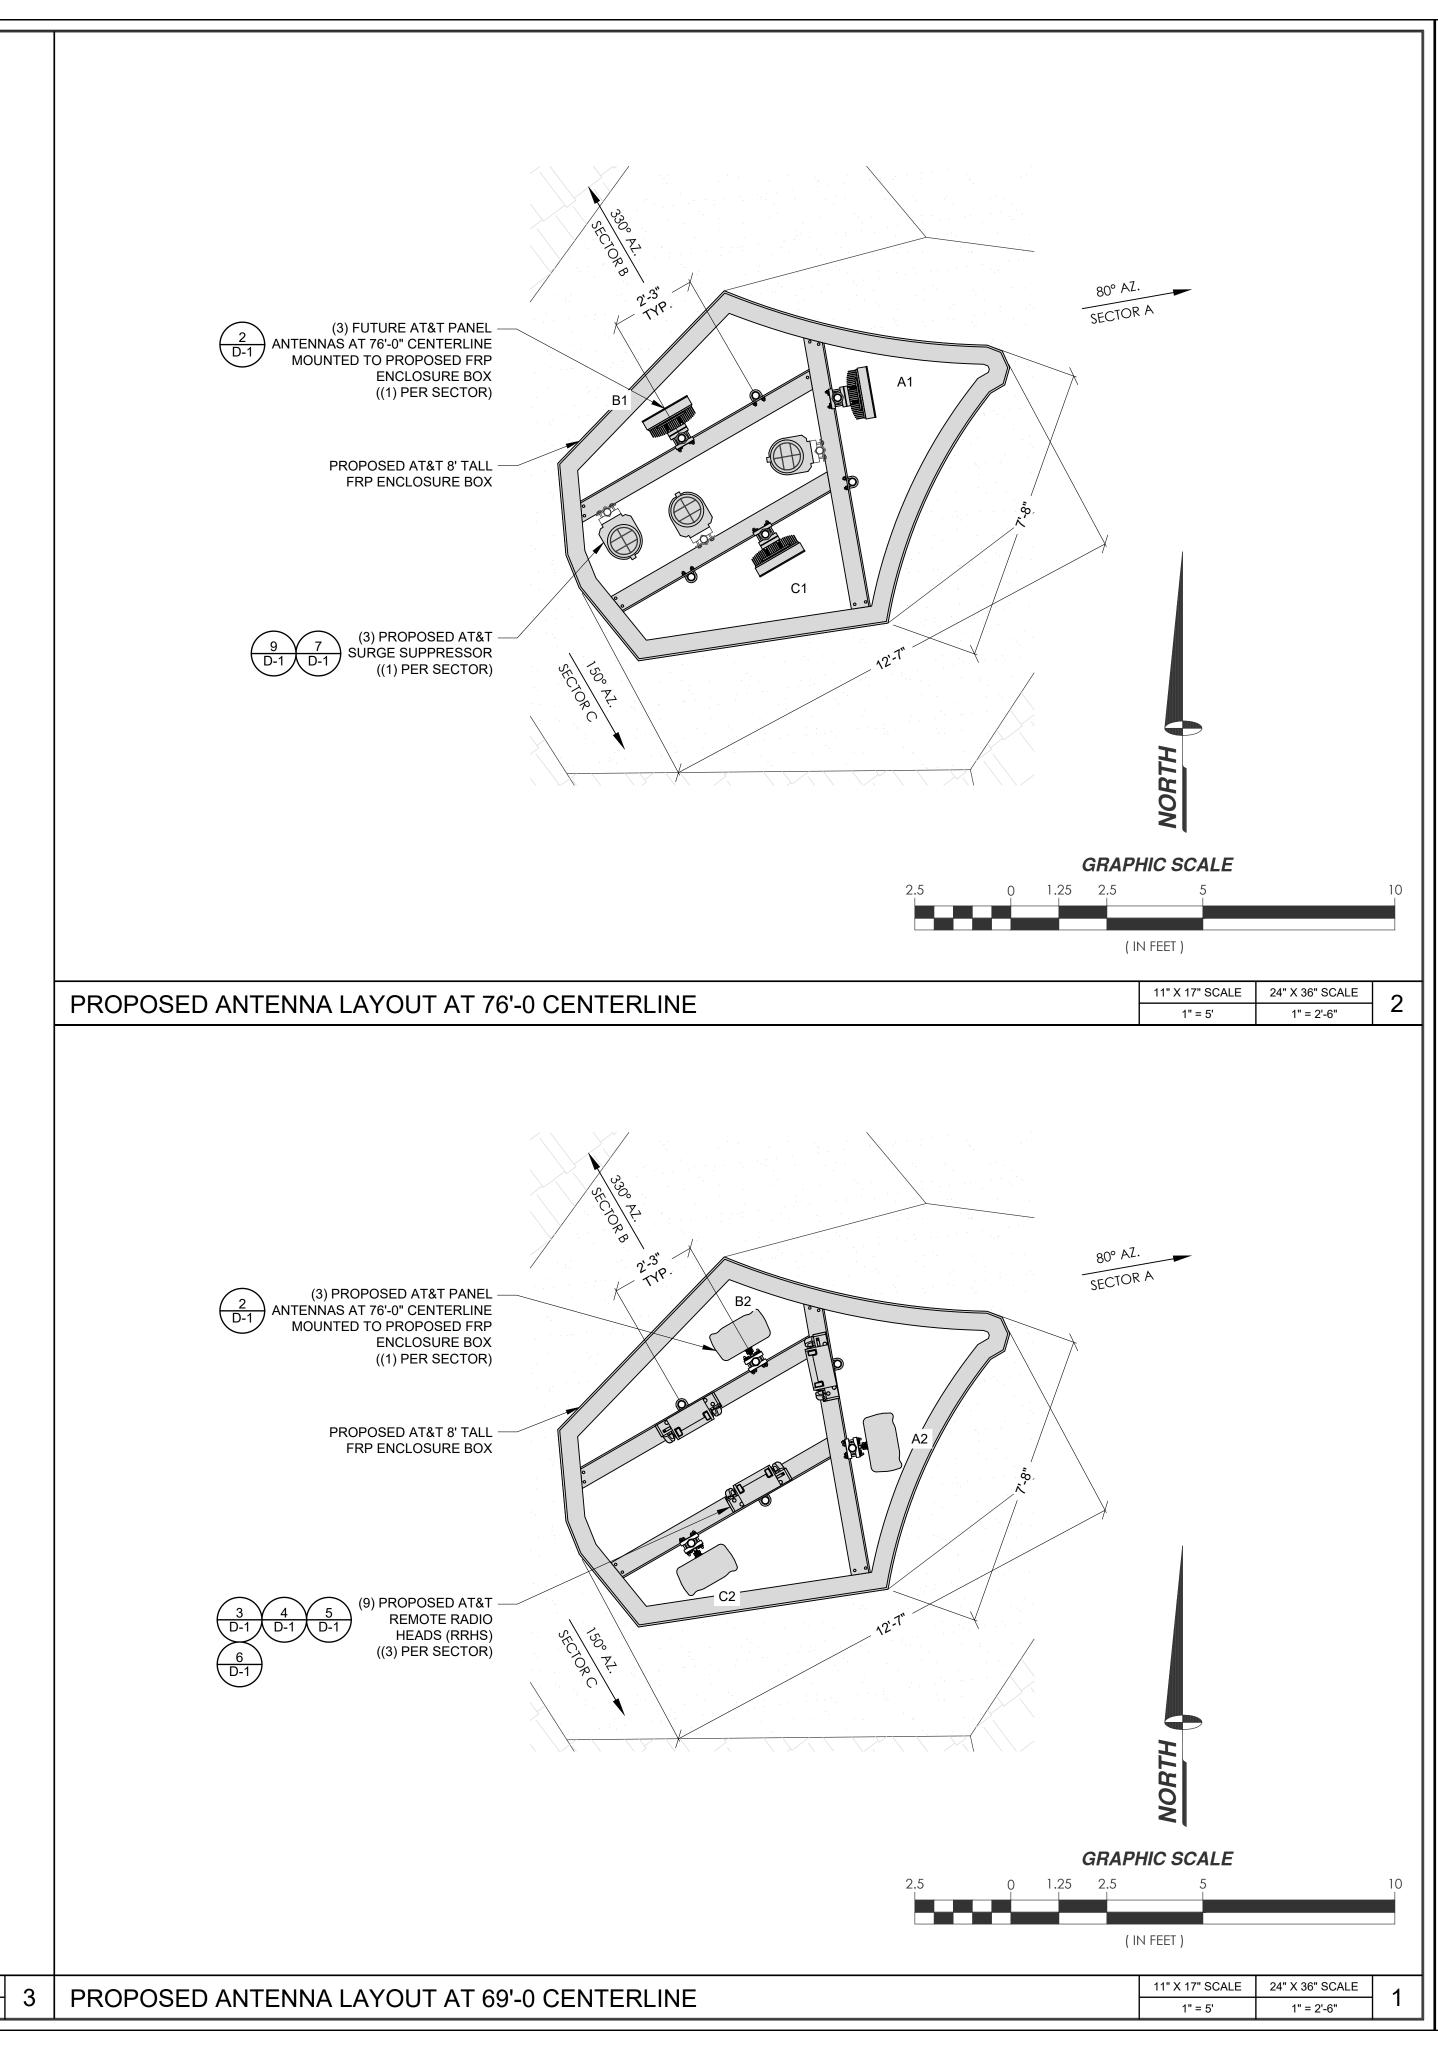

PROJECT INFORMATION:

# CCL05072 SACRED HEART

10189 SHORELINE HIGHWAY POINT REYES STATION, CA 94956

PREPARED FOR



5001 EXECUTIVE PARKWAY SAN RAMON, CALIFORNIA 94583

VENDO



SPECTRUM SERVICES, LLC. 4850 WEST OQUENDO ROAD LAS VEGAS, NEVADA 89118 PHONE: (702) 367-7705 FAX: (702) 367-8733

AT&T SITE NO: CCL05072

PROJECT NO: -

DRAWN BY: M. MARASIGAN

CHECKED BY: B. OXBORROW

APPROVED BY: C. WENER

	ISSI	JE STATUS	
REV.	DATE	DESCRIPTION	B١
0	12/01/22	90% ZONING	M.N
1	04/17/23	100% ZONING	M.N
2	02/07/24	CLIENT REVISION	M.N
3	02/14/24	PLAN CHECK	M.N


### LICENSURE:

PRELIMINARY:
NOT FOR
CONSTRUCTION

IT IS A VIOLATION OF LAW FOR ANY PERSON, UNLESS THEY ARE ACTING UNDER THE DIRECTION OF A LICENSED PROFESSIONAL ENGINEER, TO ALTER THIS DOCUMENT.

SHEET TITLE:

ANTENNA PLAN AND EQUIPMENT SCHEDULE

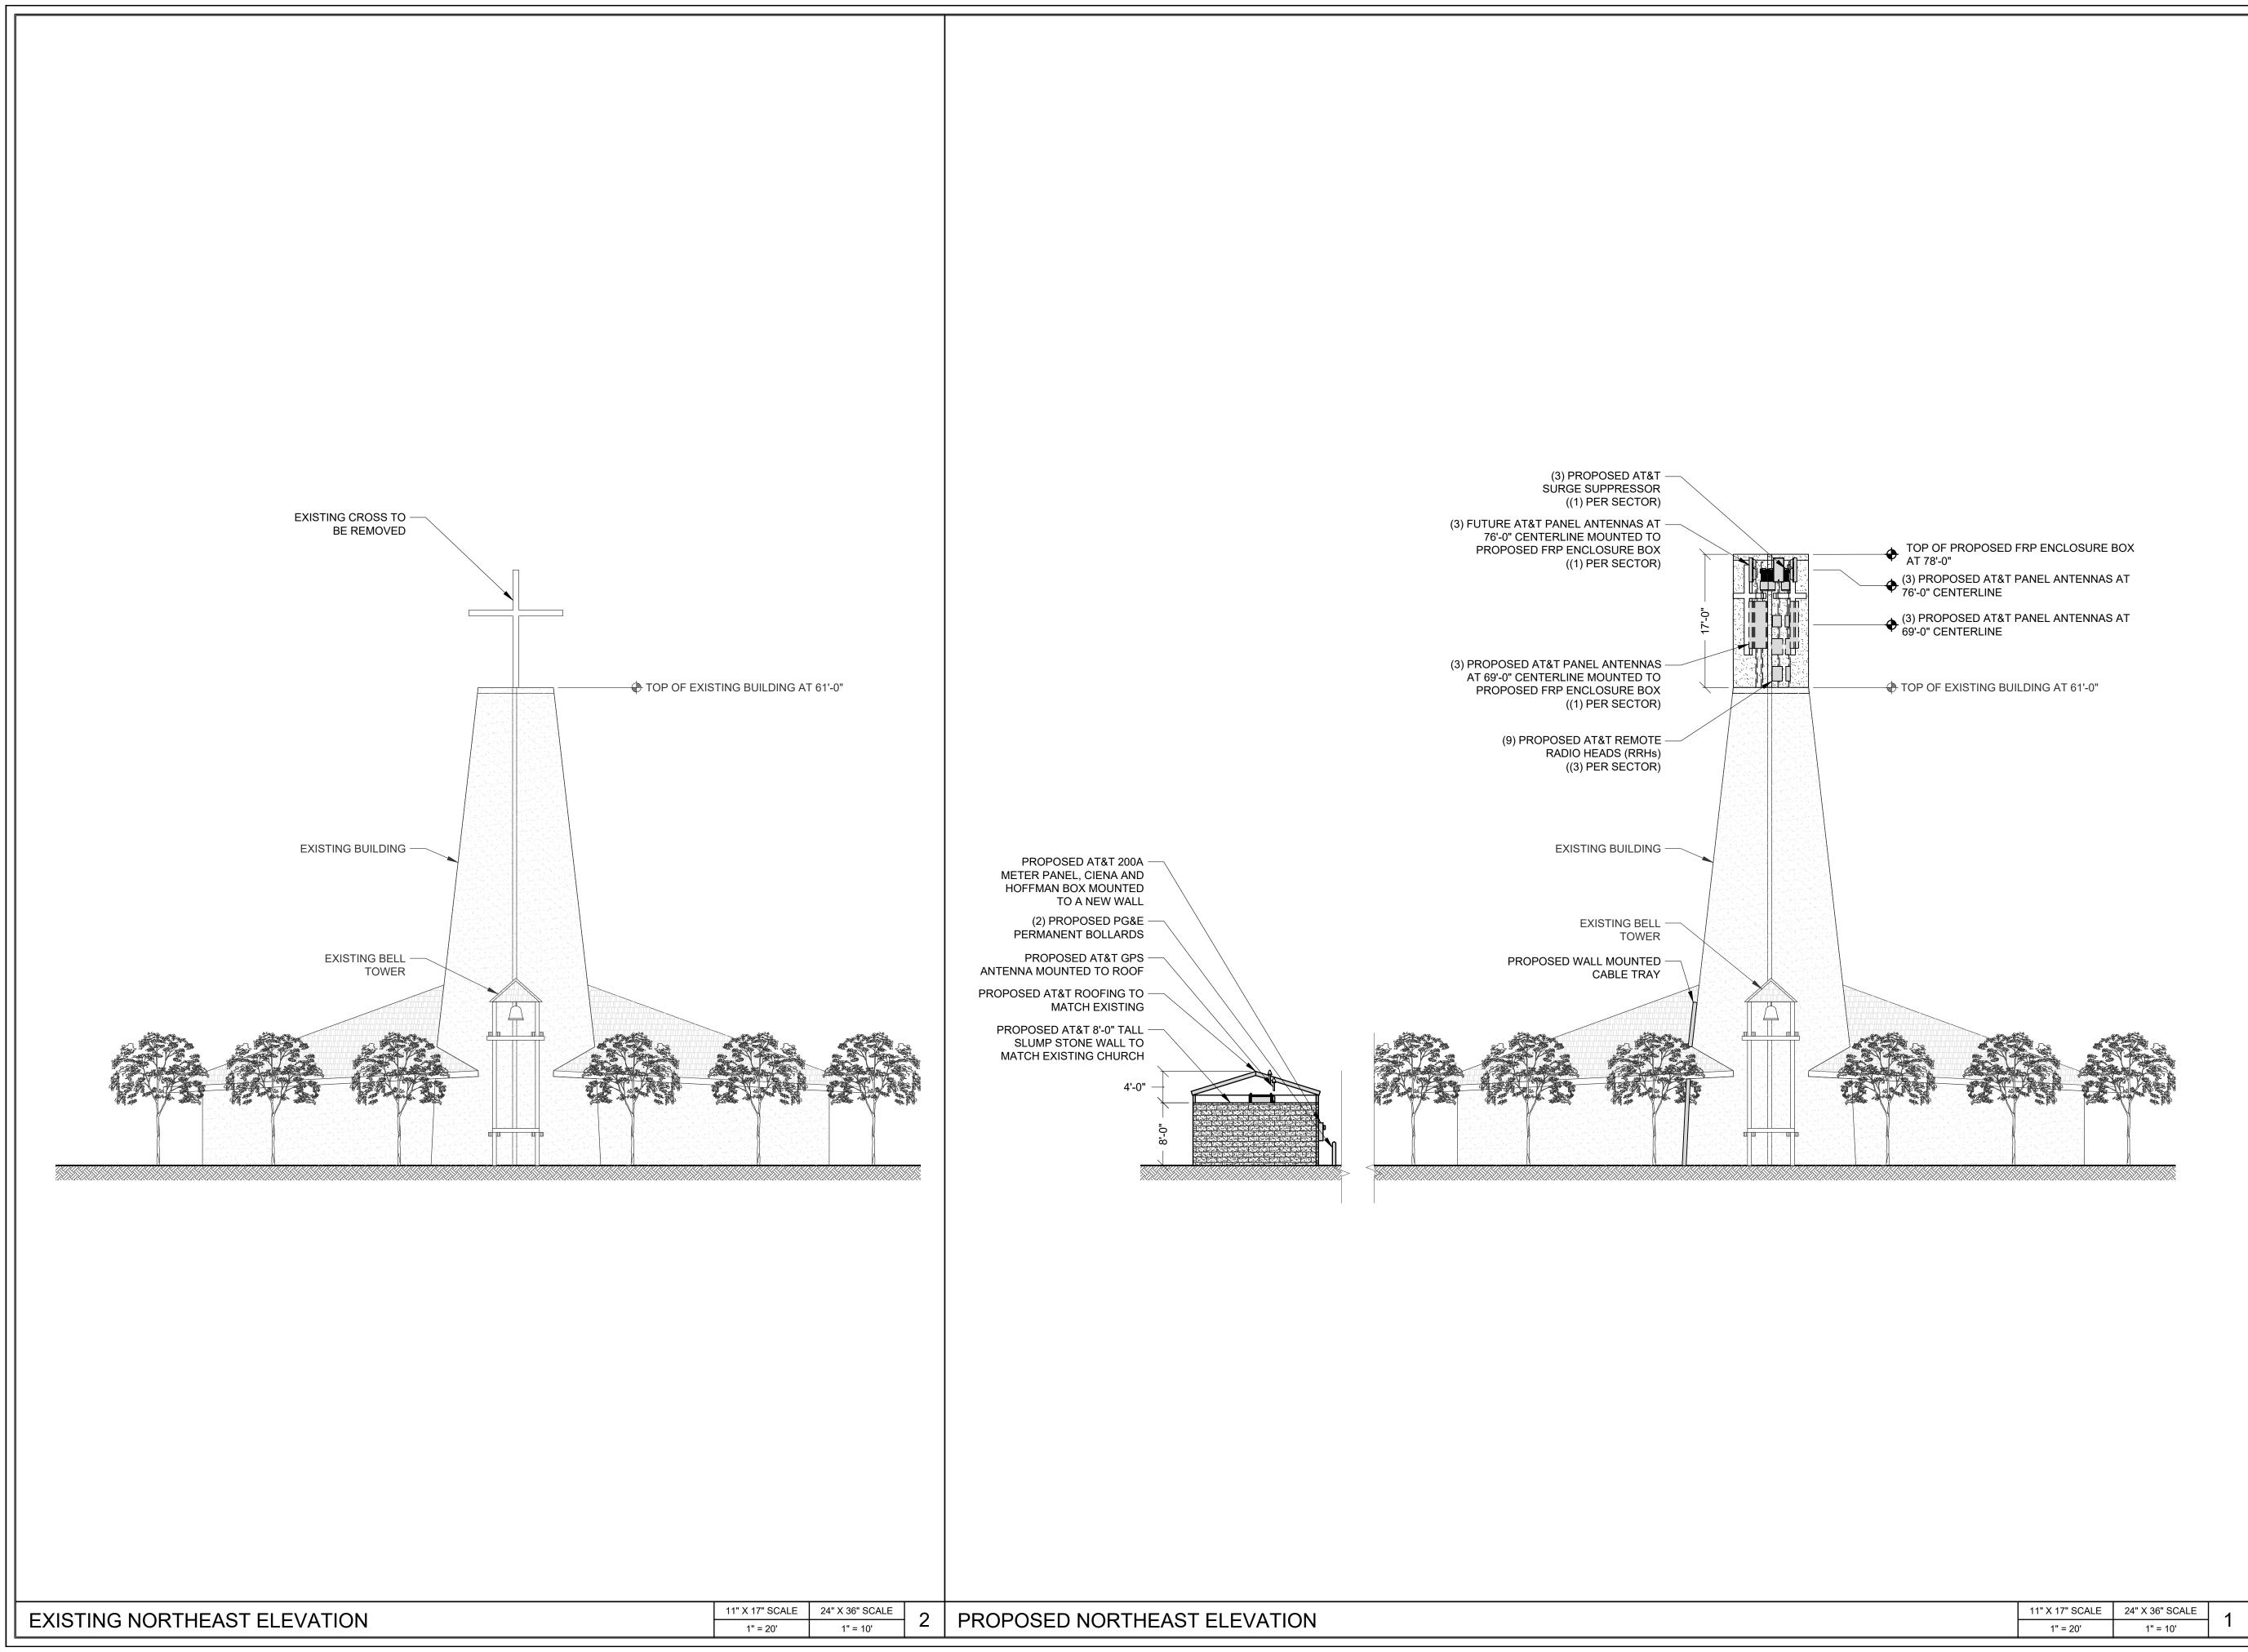

# CCL05072 SACRED HEART

10189 SHORELINE HIGHWAY POINT REYES STATION, CA 94956

PREPARED FOR



5001 EXECUTIVE PARKWAY SAN RAMON, CALIFORNIA 94583

VENDOR:



SPECTRUM SERVICES, LLC. 4850 WEST OQUENDO ROAD LAS VEGAS, NEVADA 89118 PHONE: (702) 367-7705 FAX: (702) 367-8733

AT&T SITE NO: CCL05072

PROJECT NO: -

DRAWN BY: M. MARASIGAN

CHECKED BY: B. OXBORROW

APPROVED BY: C. WENER

_				
ISSUE STATUS				
REV.	DATE	DESCRIPTION	BY	
0	12/01/22	90% ZONING	M.M.	
1	04/17/23	100% ZONING	M.M.	
2	02/07/24	CLIENT REVISION	M.M.	
3	02/14/24	PLAN CHECK	M.M	


LICENSURE:

PRELIMINARY:
NOT FOR
CONSTRUCTION

IT IS A VIOLATION OF LAW FOR ANY PERSON, UNLESS THEY ARE ACTING UNDER THE DIRECTION OF A LICENSED PROFESSIONAL ENGINEER, TO ALTER THIS DOCUMENT.

SHEET TITLE:

EXISTING AND PROPOSED NORTHEAST ELEVATIONS

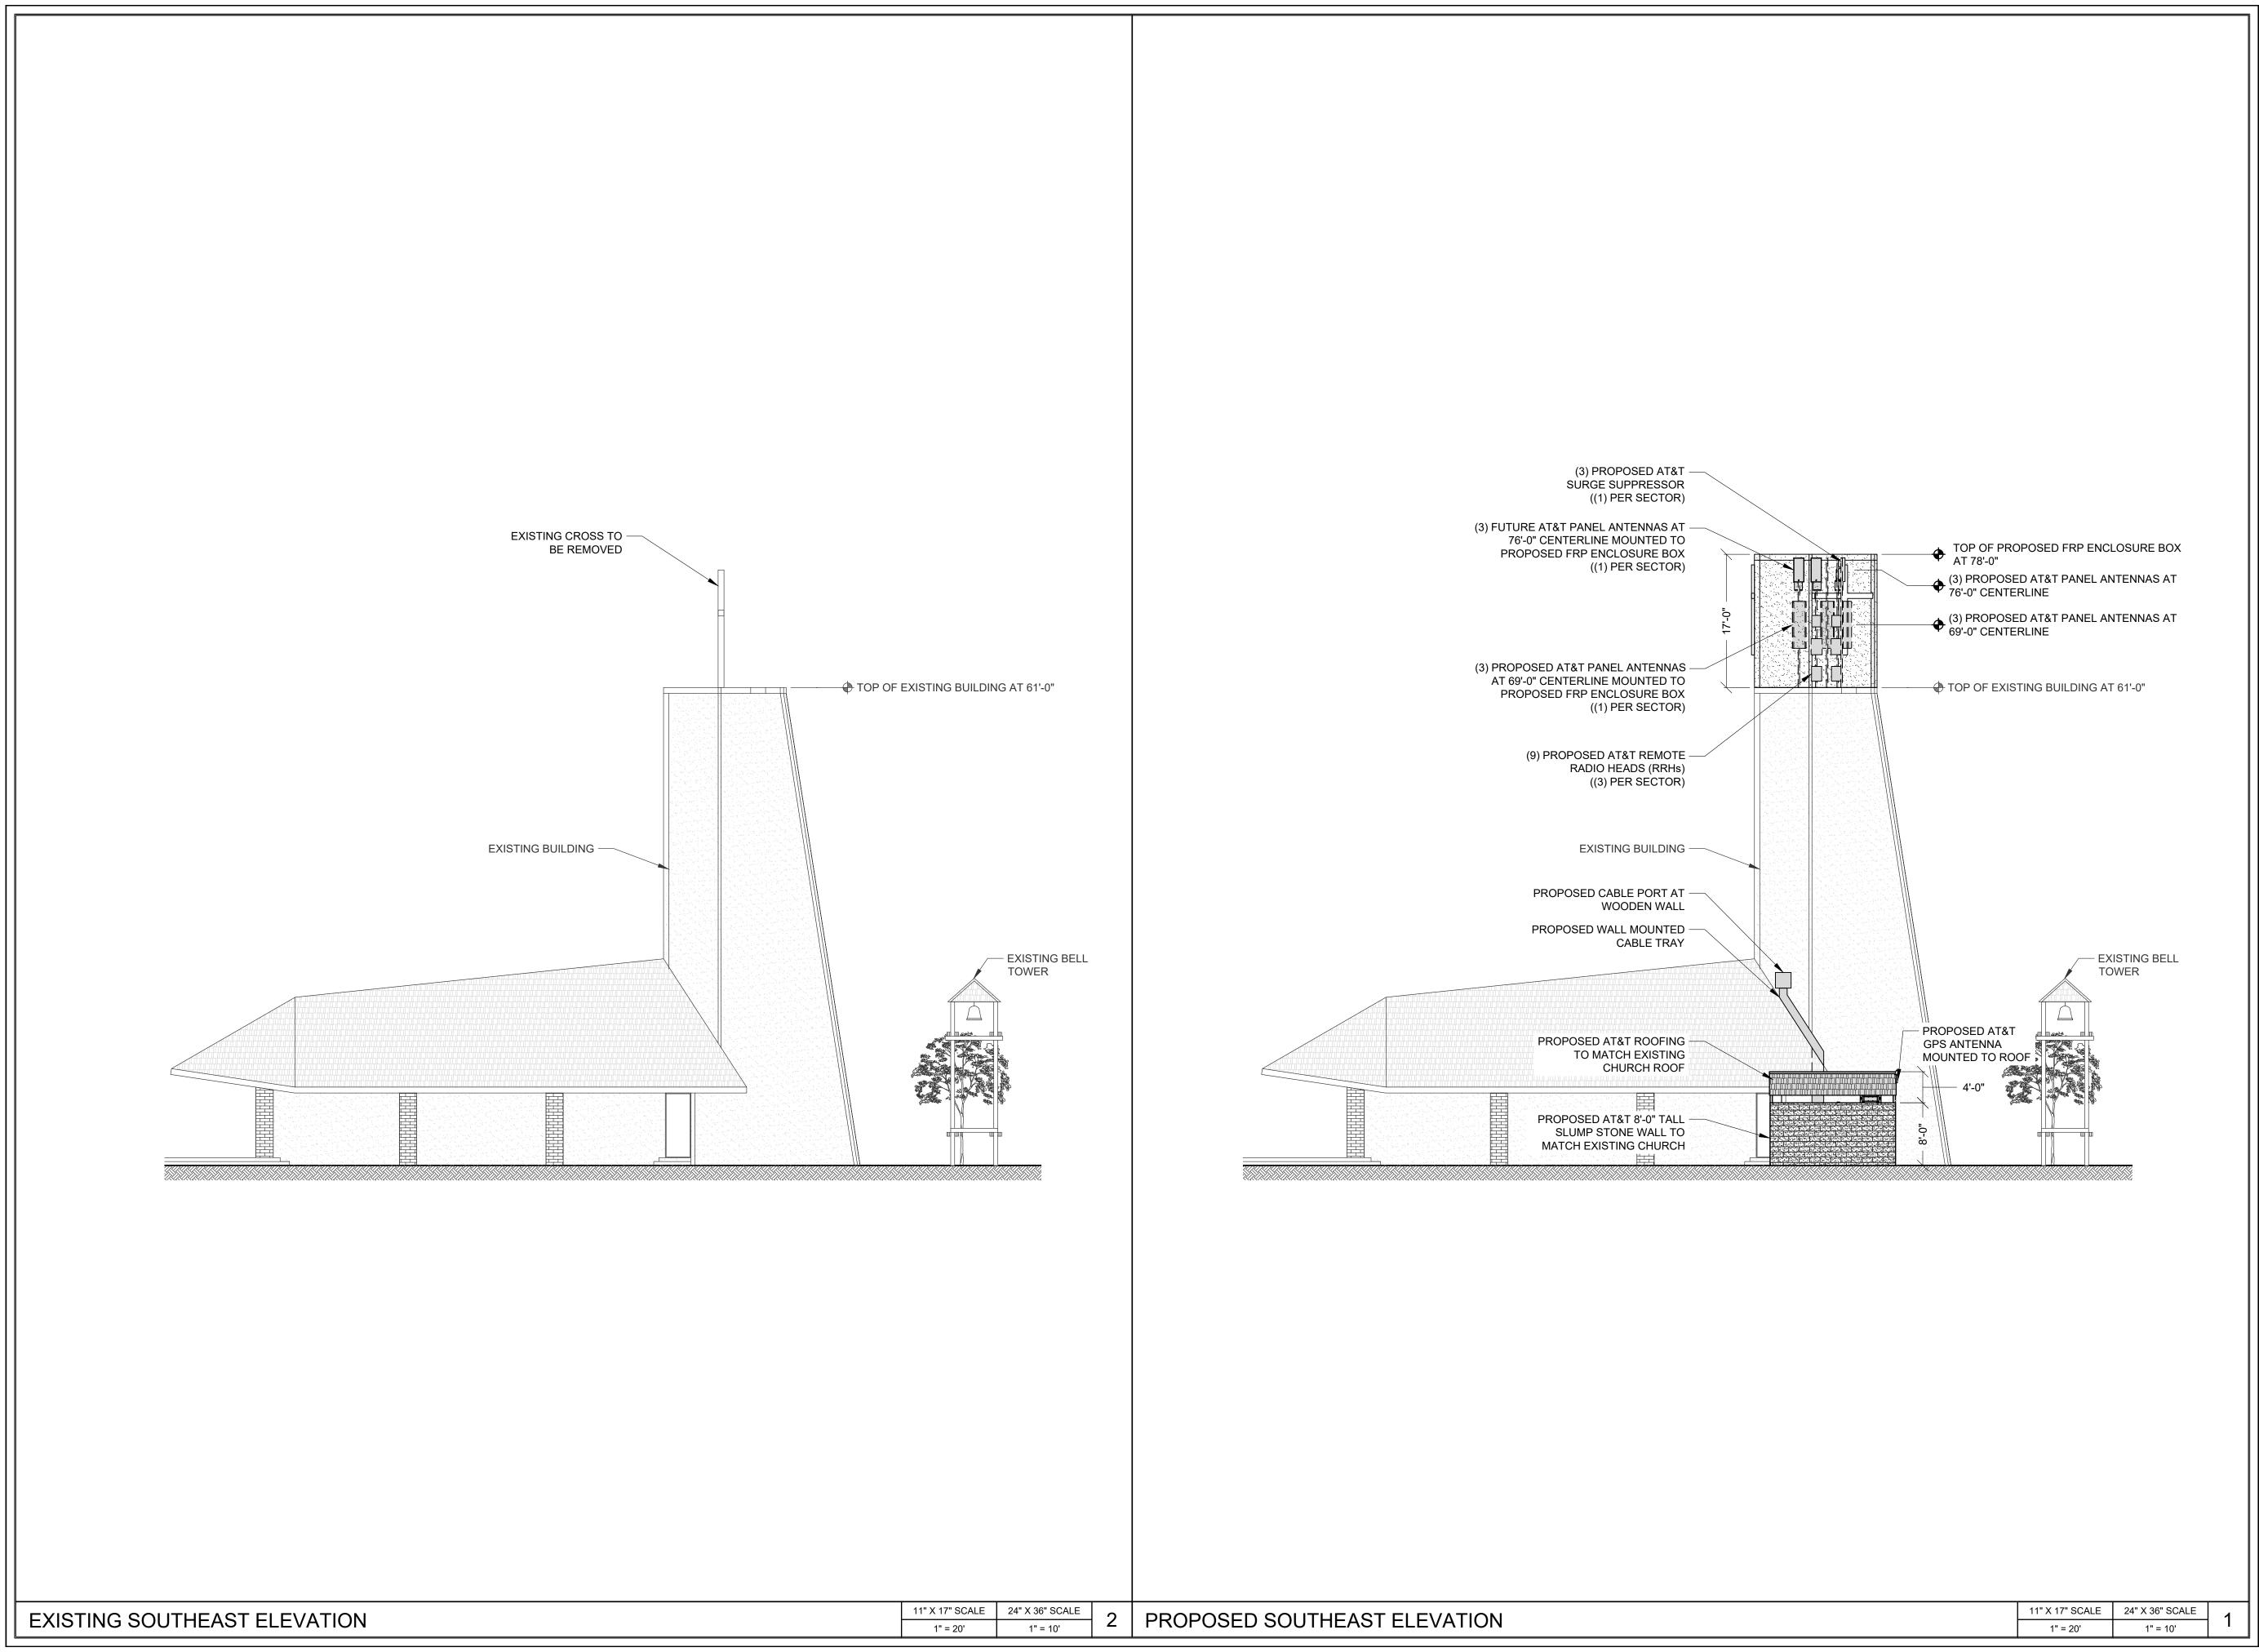

# CCL05072 SACRED HEART

10189 SHORELINE HIGHWAY POINT REYES STATION, CA 94956

PREPARED FOR



5001 EXECUTIVE PARKWAY SAN RAMON, CALIFORNIA 94583

VENDOR:



SPECTRUM SERVICES, LLC. 4850 WEST OQUENDO ROAD LAS VEGAS, NEVADA 89118 PHONE: (702) 367-7705 FAX: (702) 367-8733

AT&T SITE NO: CCL05072

PROJECT NO: -

DRAWN BY: M. MARASIGAN

CHECKED BY: B. OXBORROW

APPROVED BY: C. WENER

ISSUE STATUS				
REV.	DATE	DESCRIPTION	BY	
0	12/01/22	90% ZONING	M.M.	
1	04/17/23	100% ZONING	M.M.	
2	02/07/24	CLIENT REVISION	M.M.	
3	02/14/24	PLAN CHECK	M.M.	


LICENSURE:

PRELIMINARY:
NOT FOR
CONSTRUCTION

IT IS A VIOLATION OF LAW FOR ANY PERSON, UNLESS THEY ARE ACTING UNDER THE DIRECTION OF A LICENSED PROFESSIONAL ENGINEER, TO ALTER THIS DOCUMENT.

SHEET TITLE:

EXISTING AND PROPOSED SOUTHEAST ELEVATIONS

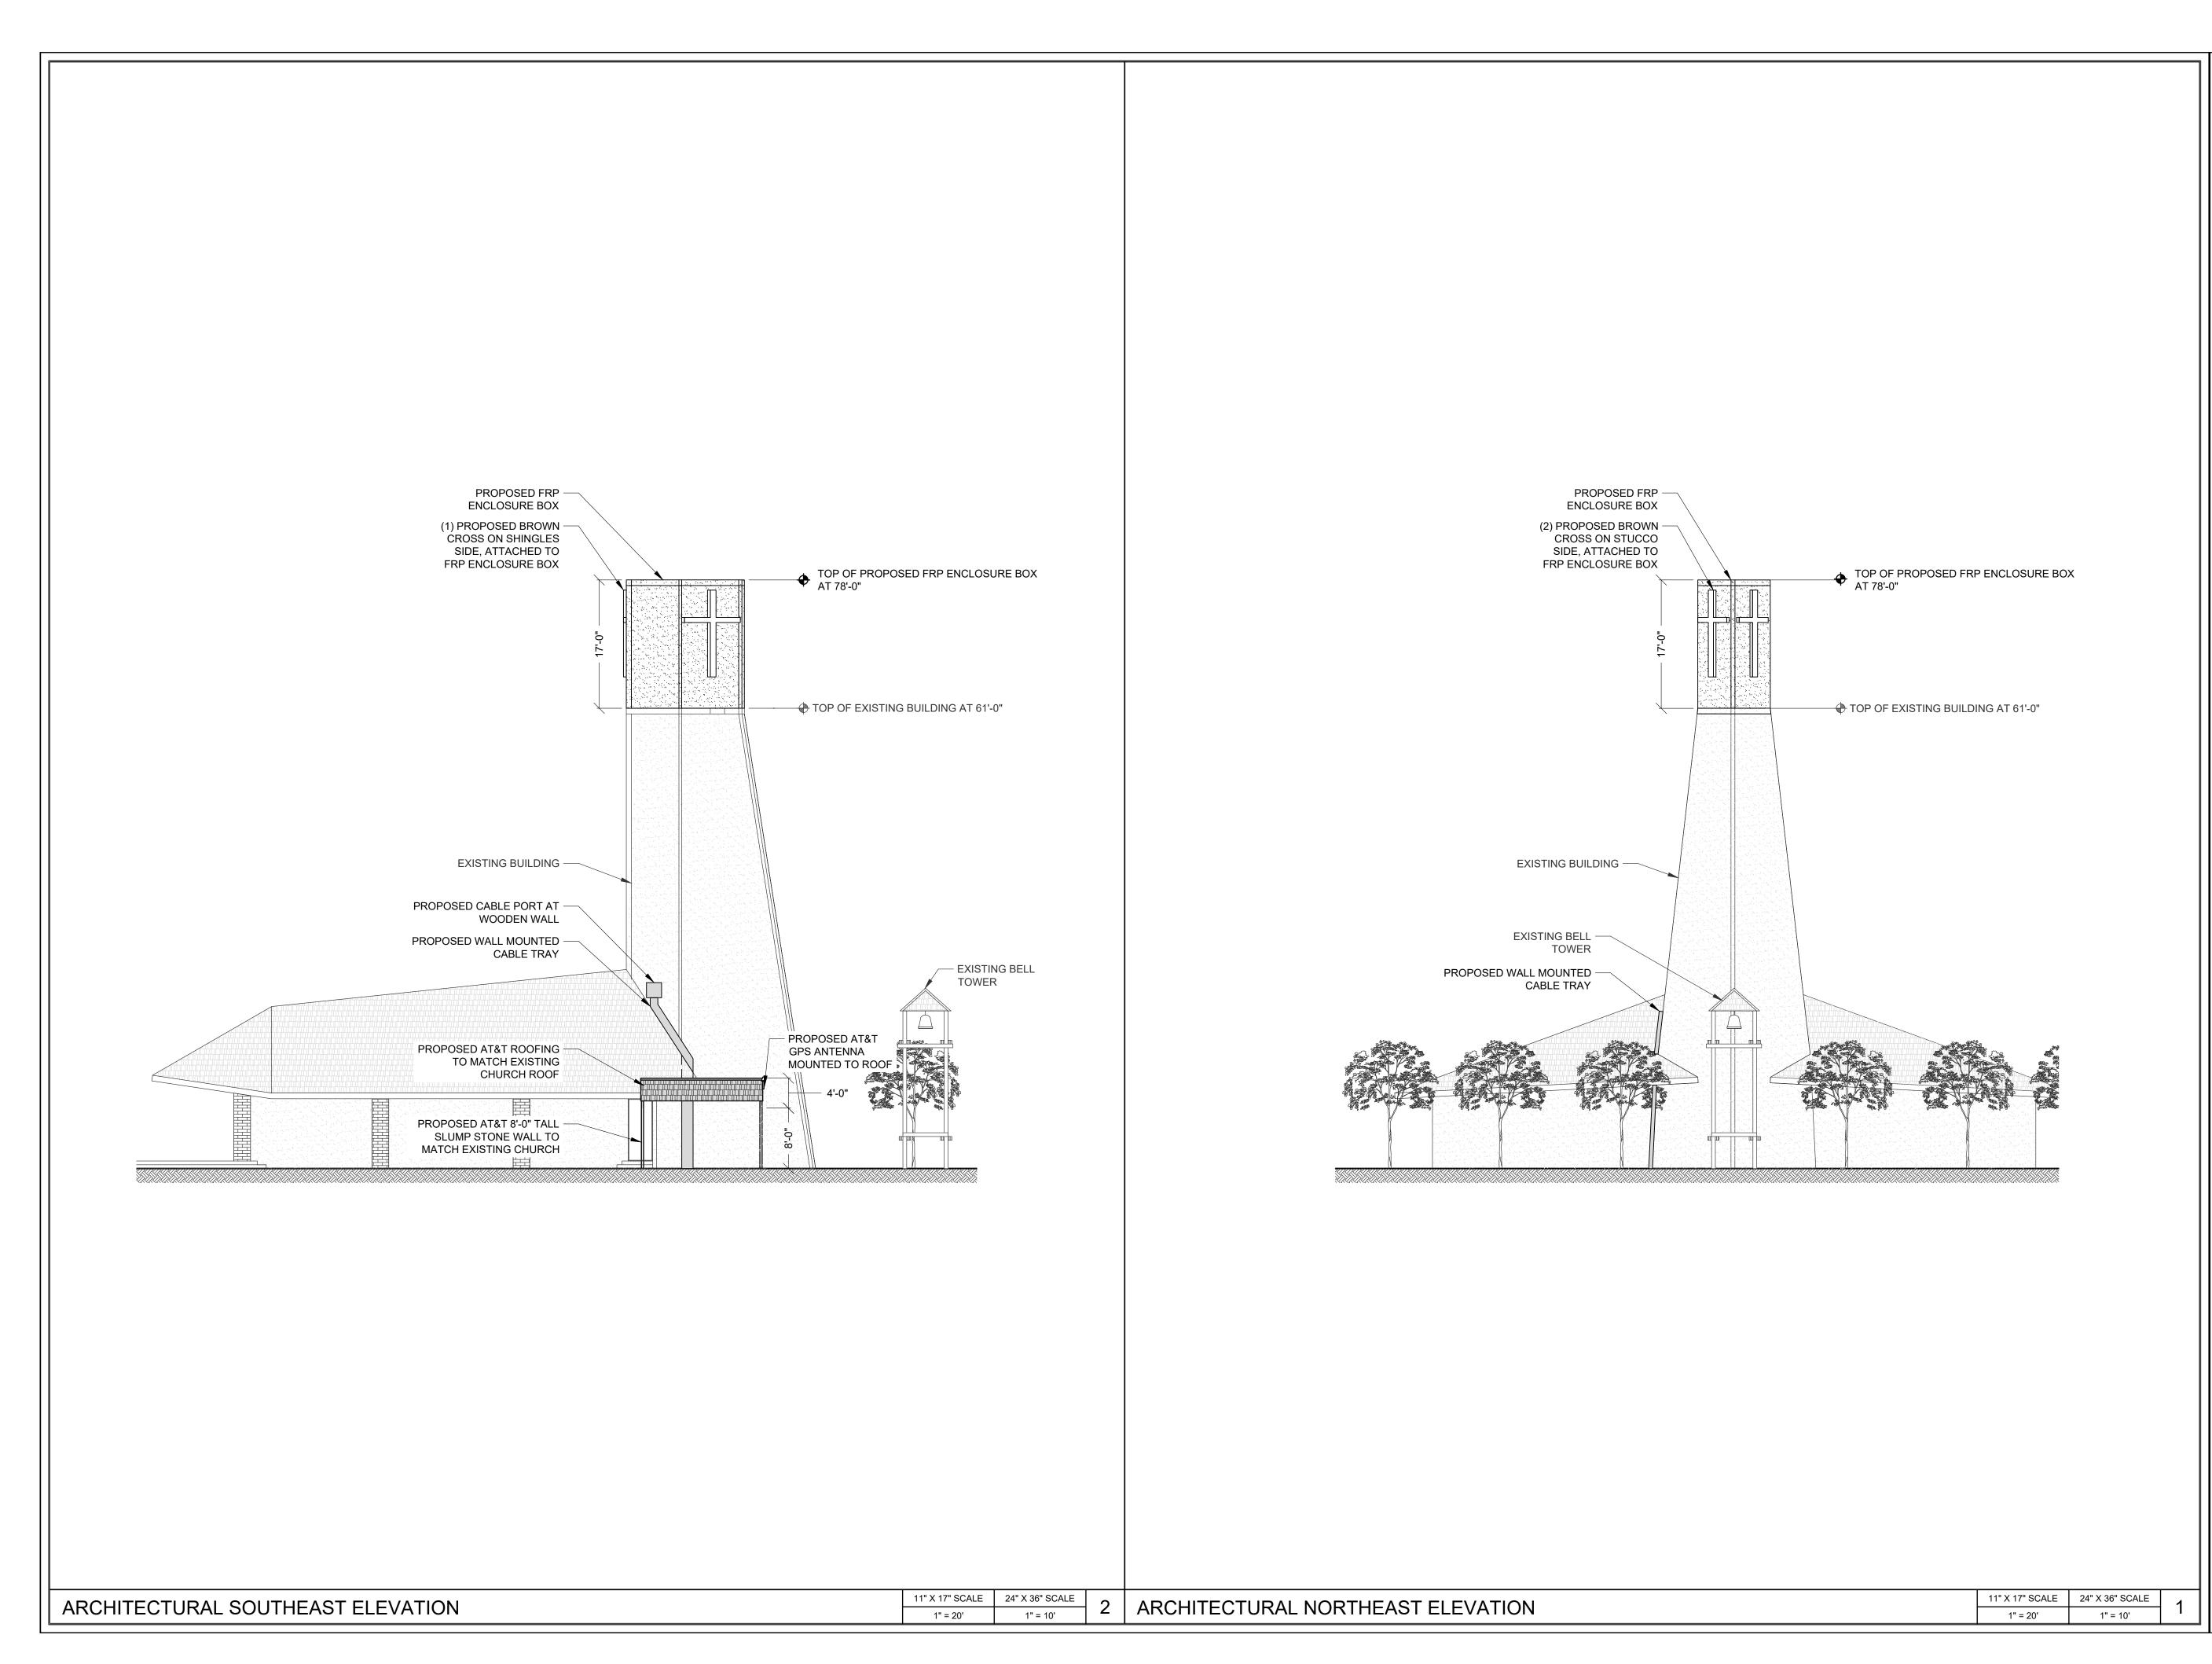

# CCL05072 SACRED HEART

10189 SHORELINE HIGHWAY POINT REYES STATION, CA 94956

PREPARED FOR



5001 EXECUTIVE PARKWAY SAN RAMON, CALIFORNIA 94583



SPECTRUM SERVICES, LLC. 4850 WEST OQUENDO ROAD LAS VEGAS, NEVADA 89118 PHONE: (702) 367-7705 FAX: (702) 367-8733

AT&T SITE NO: CCL05072

PROJECT NO: -

CHECKED BY: B. OXBORROW

DRAWN BY: M. MARASIGAN

APPROVED BY: C. WENER

ISSUE STATUS				
REV.	DATE	DESCRIPTION	BY	
0	12/01/22	90% ZONING	M.M.	
1	04/17/23	100% ZONING	M.M.	
2	02/07/24	CLIENT REVISION	M.M.	
3	02/14/24	PLAN CHECK	M.M.	


LICENSURE:


PRELIMINARY: CONSTRUCTION


IT IS A VIOLATION OF LAW FOR ANY PERSON, UNLESS THEY ARE ACTING UNDER THE DIRECTION OF A LICENSED PROFESSIONAL ENGINEER, TO ALTER THIS DOCUMENT.


SHEET TITLE: ARCHITECTURAL

NORTHEAST AND SOUTHEAST ELEVATIONS

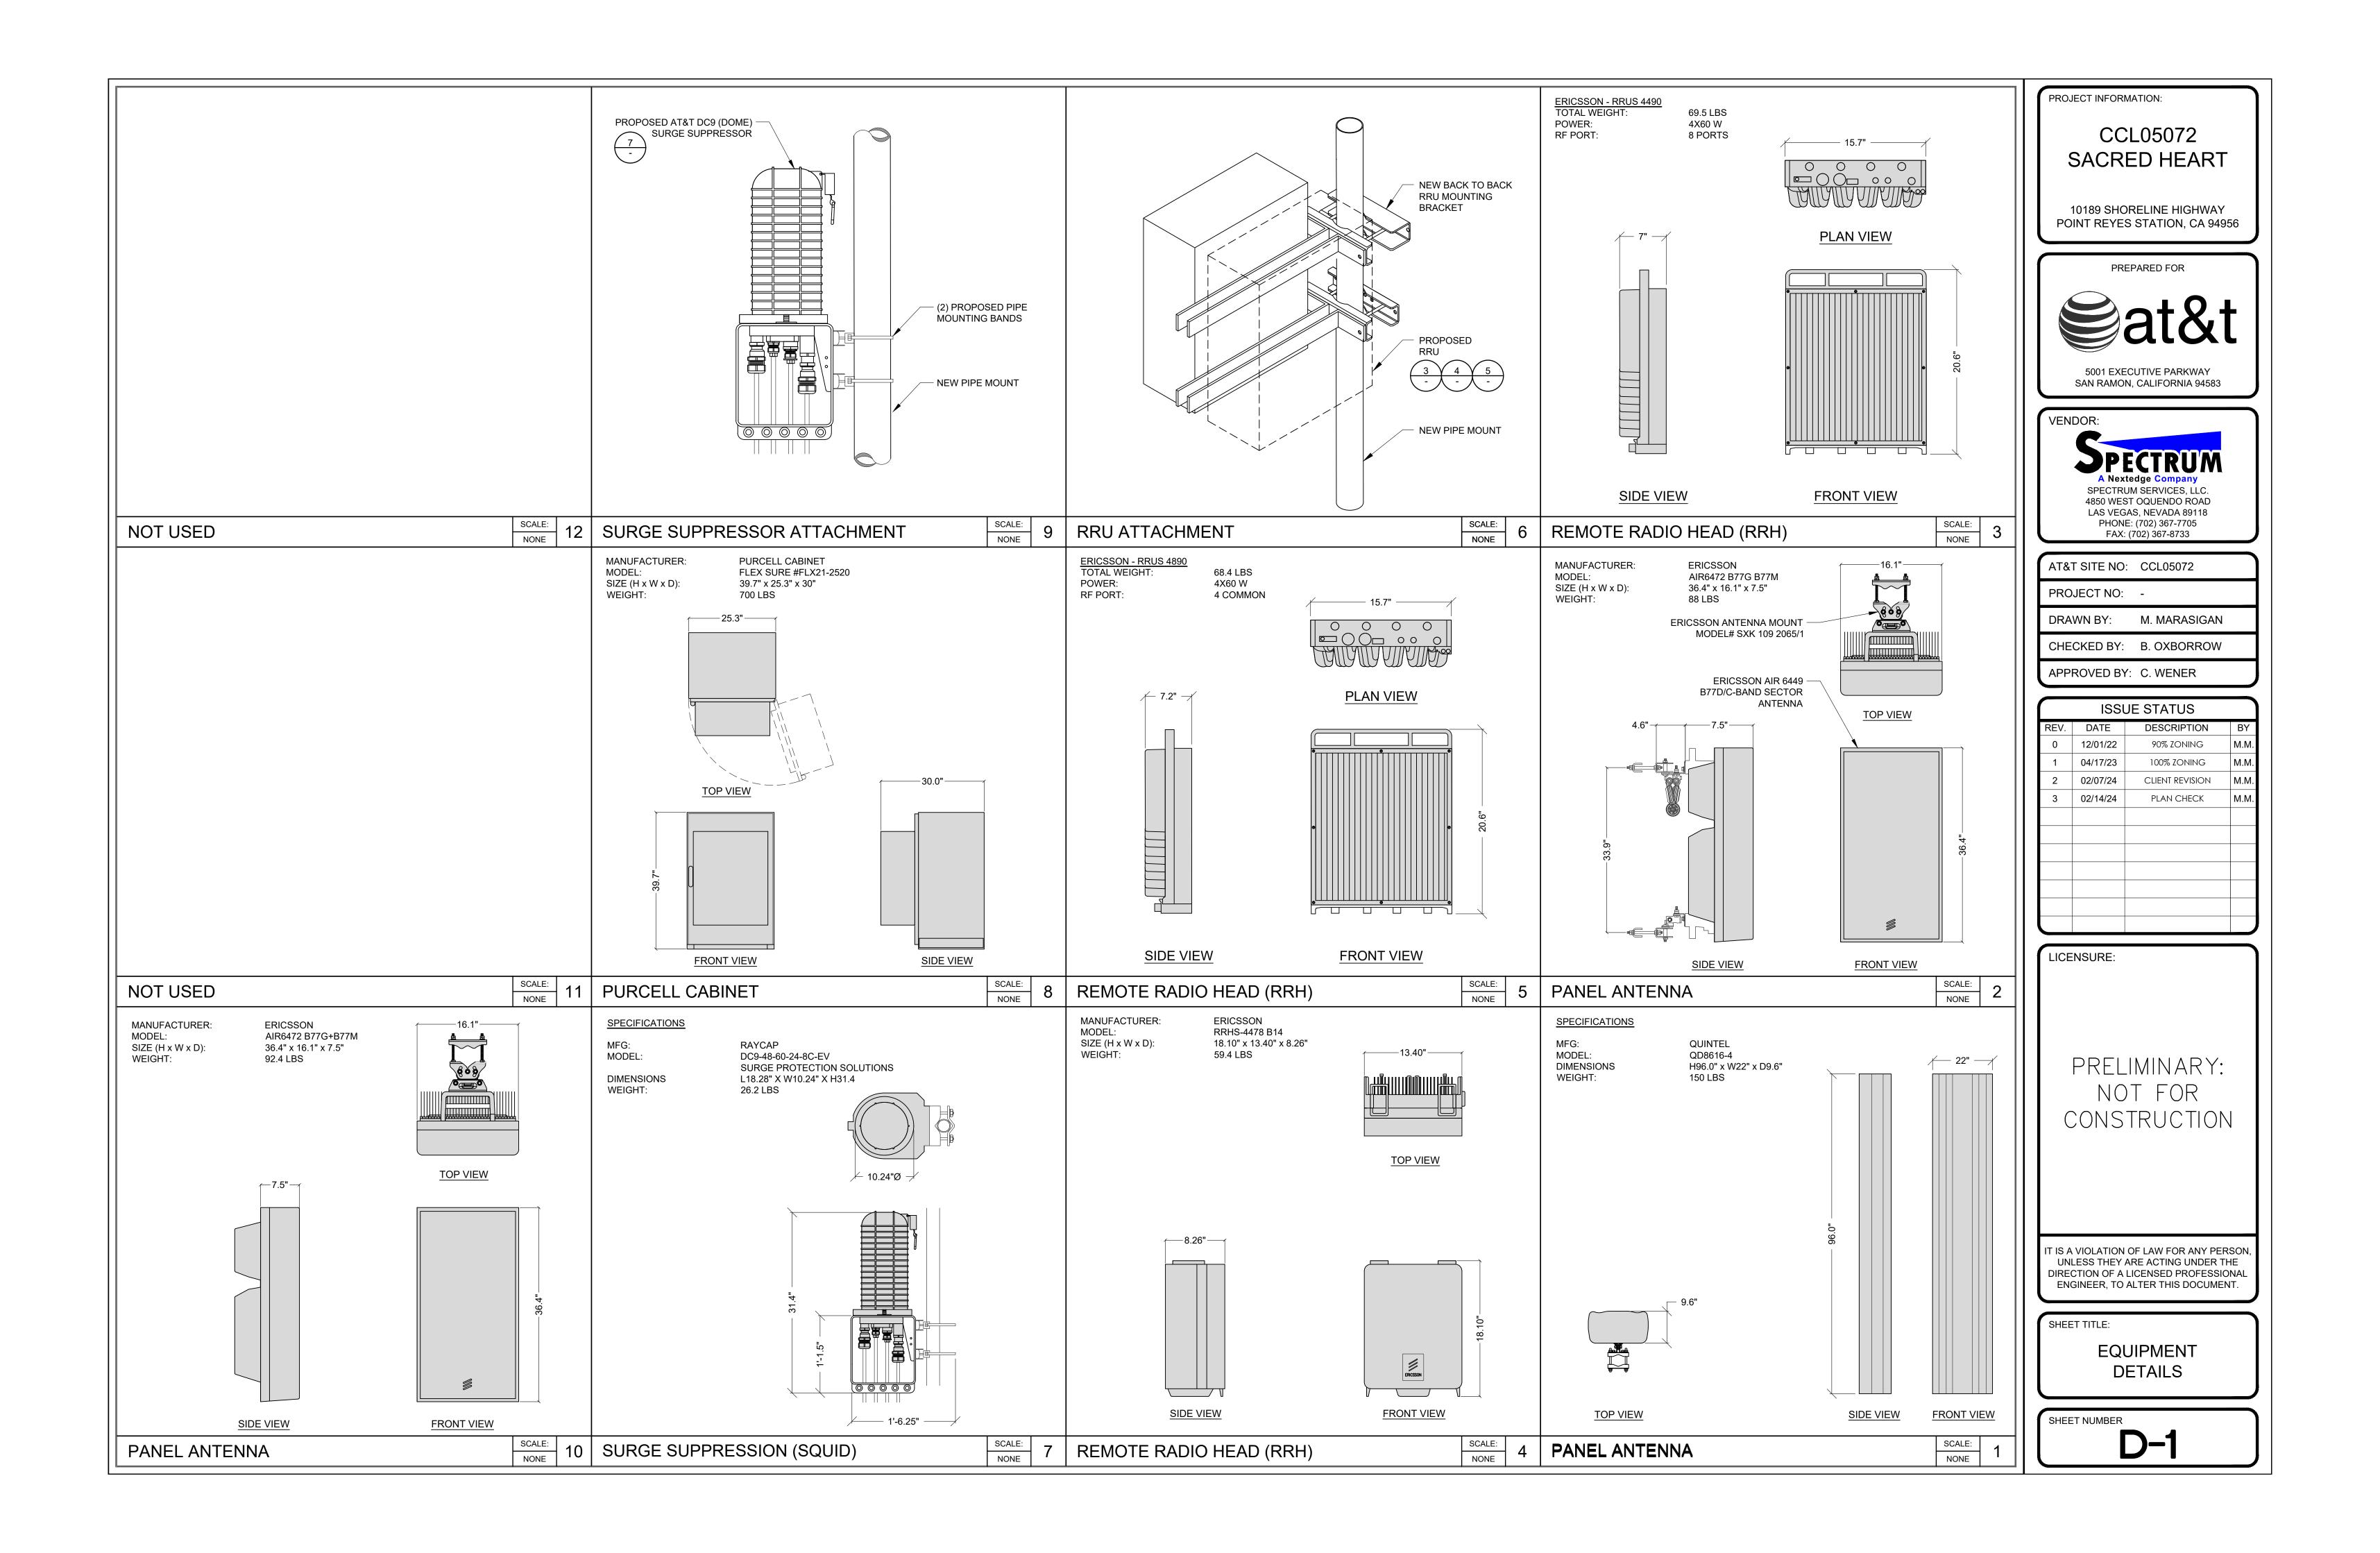

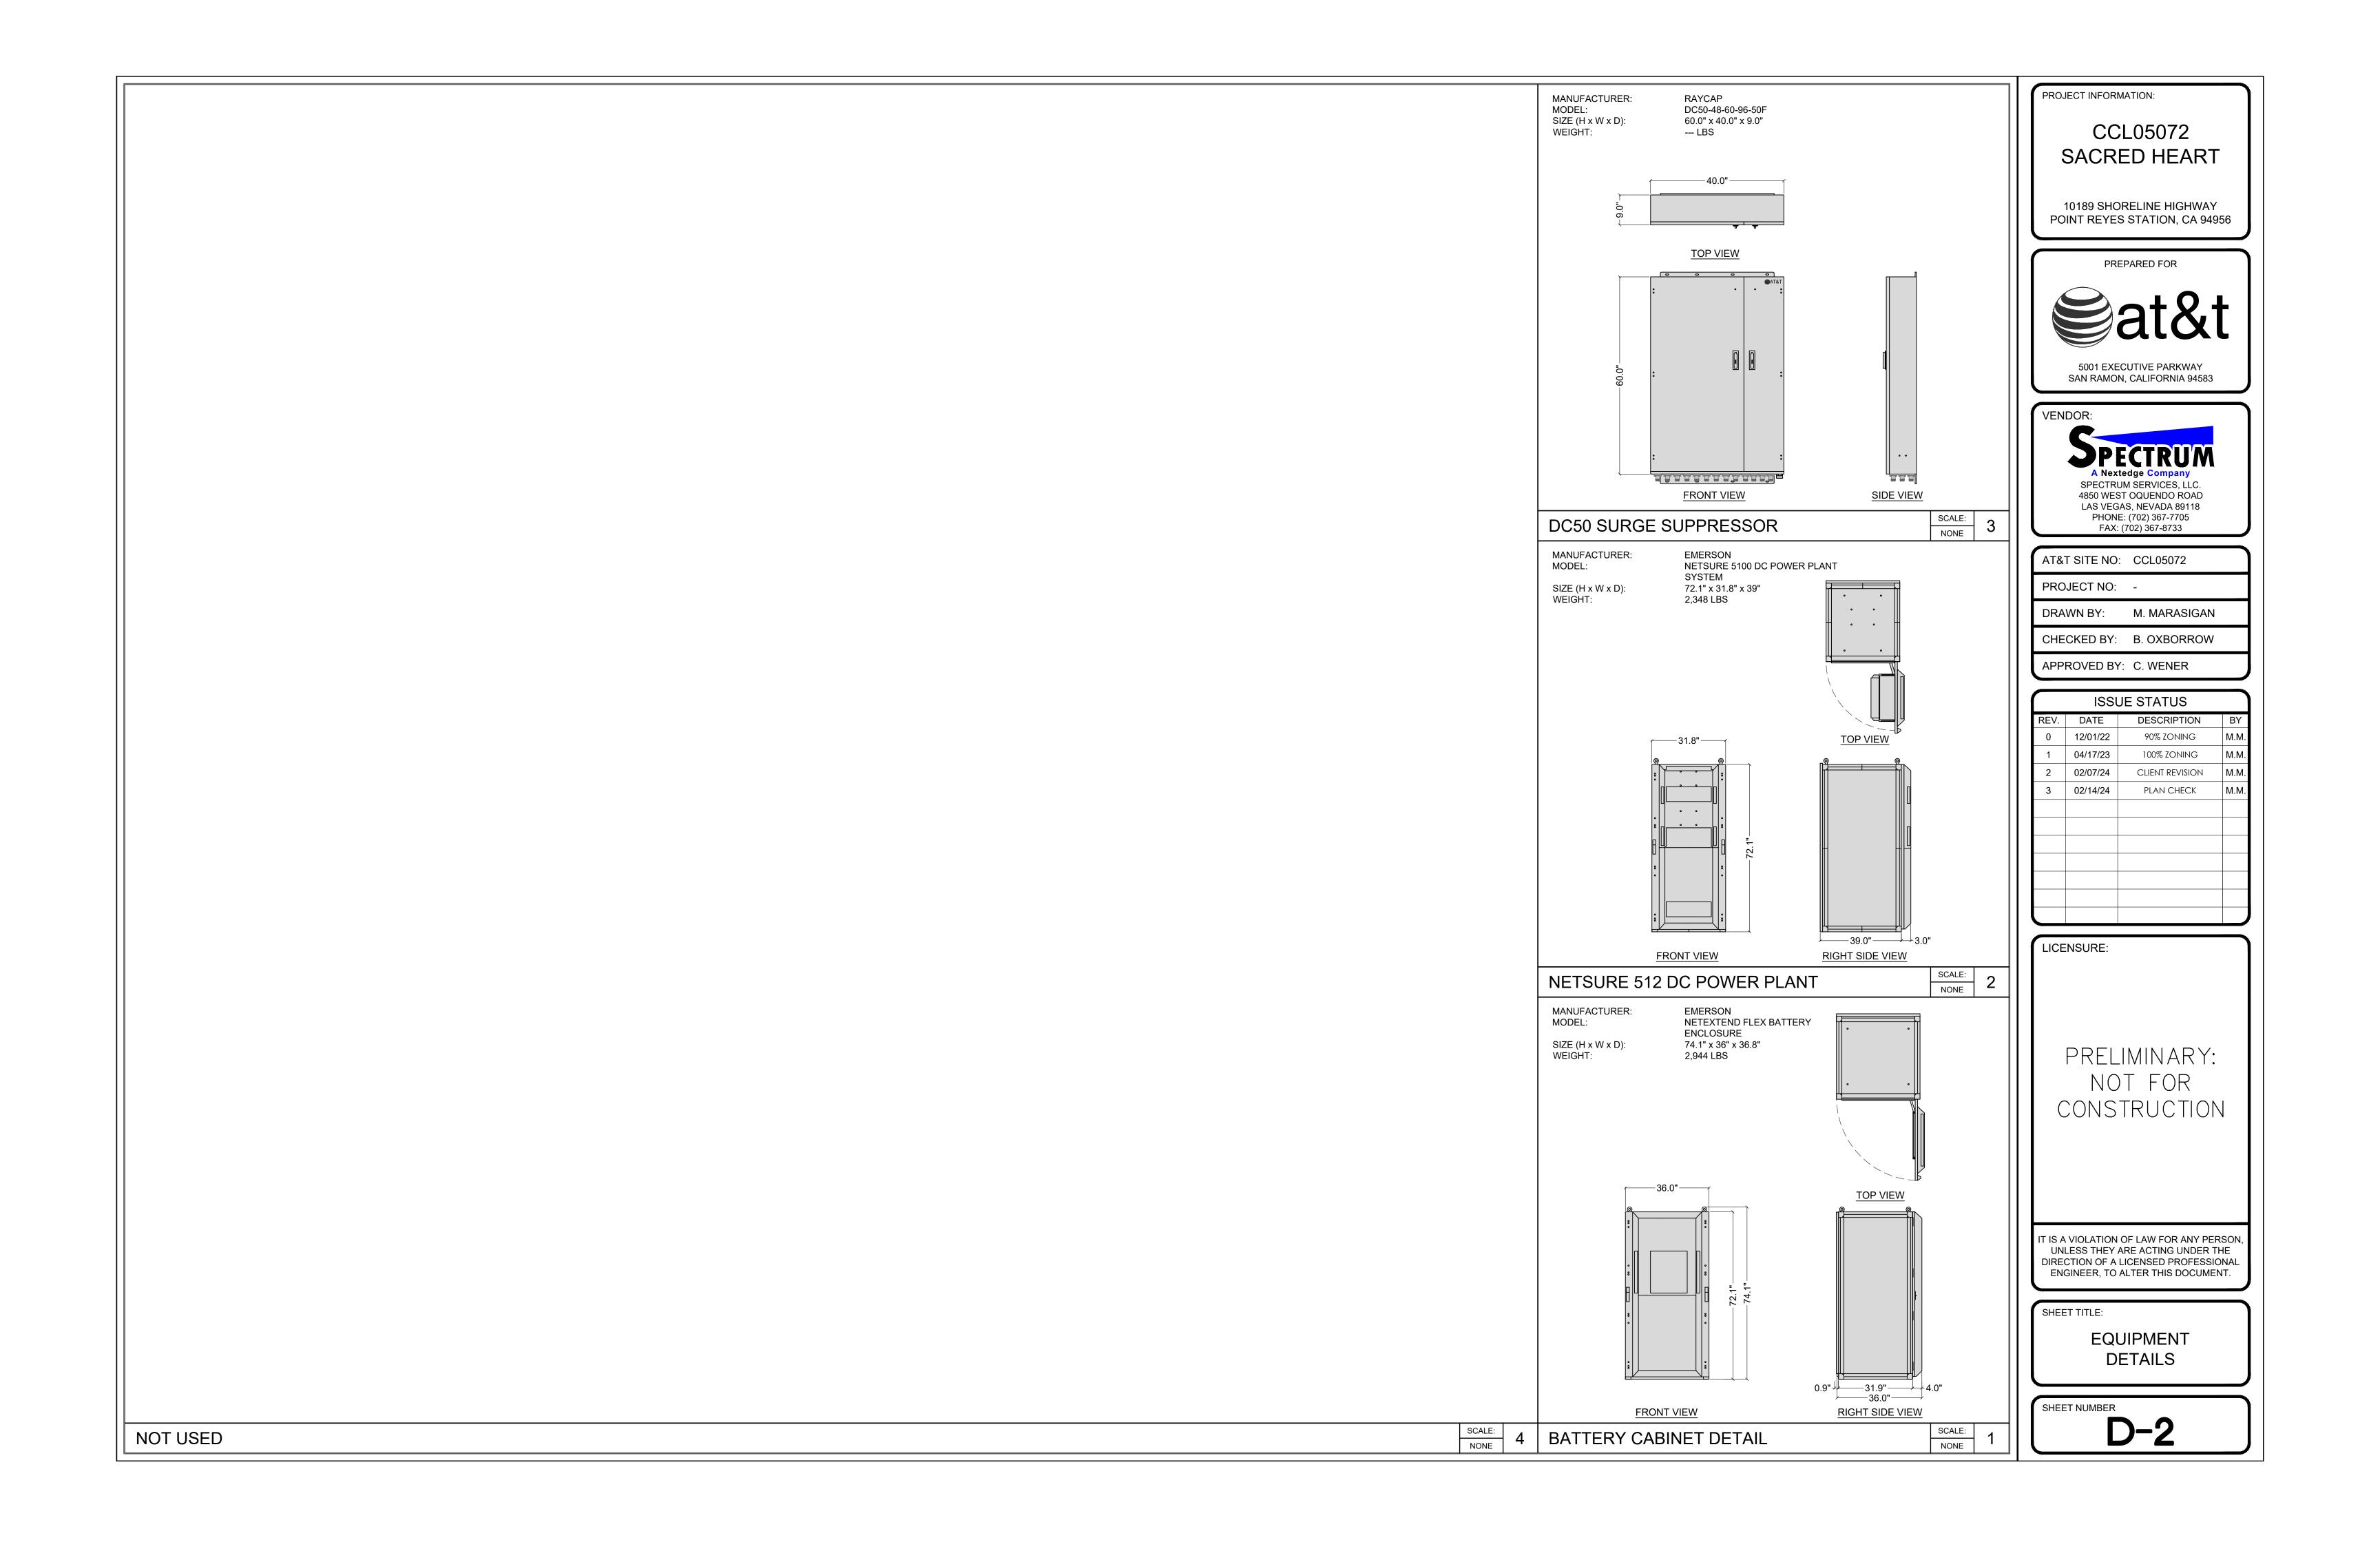

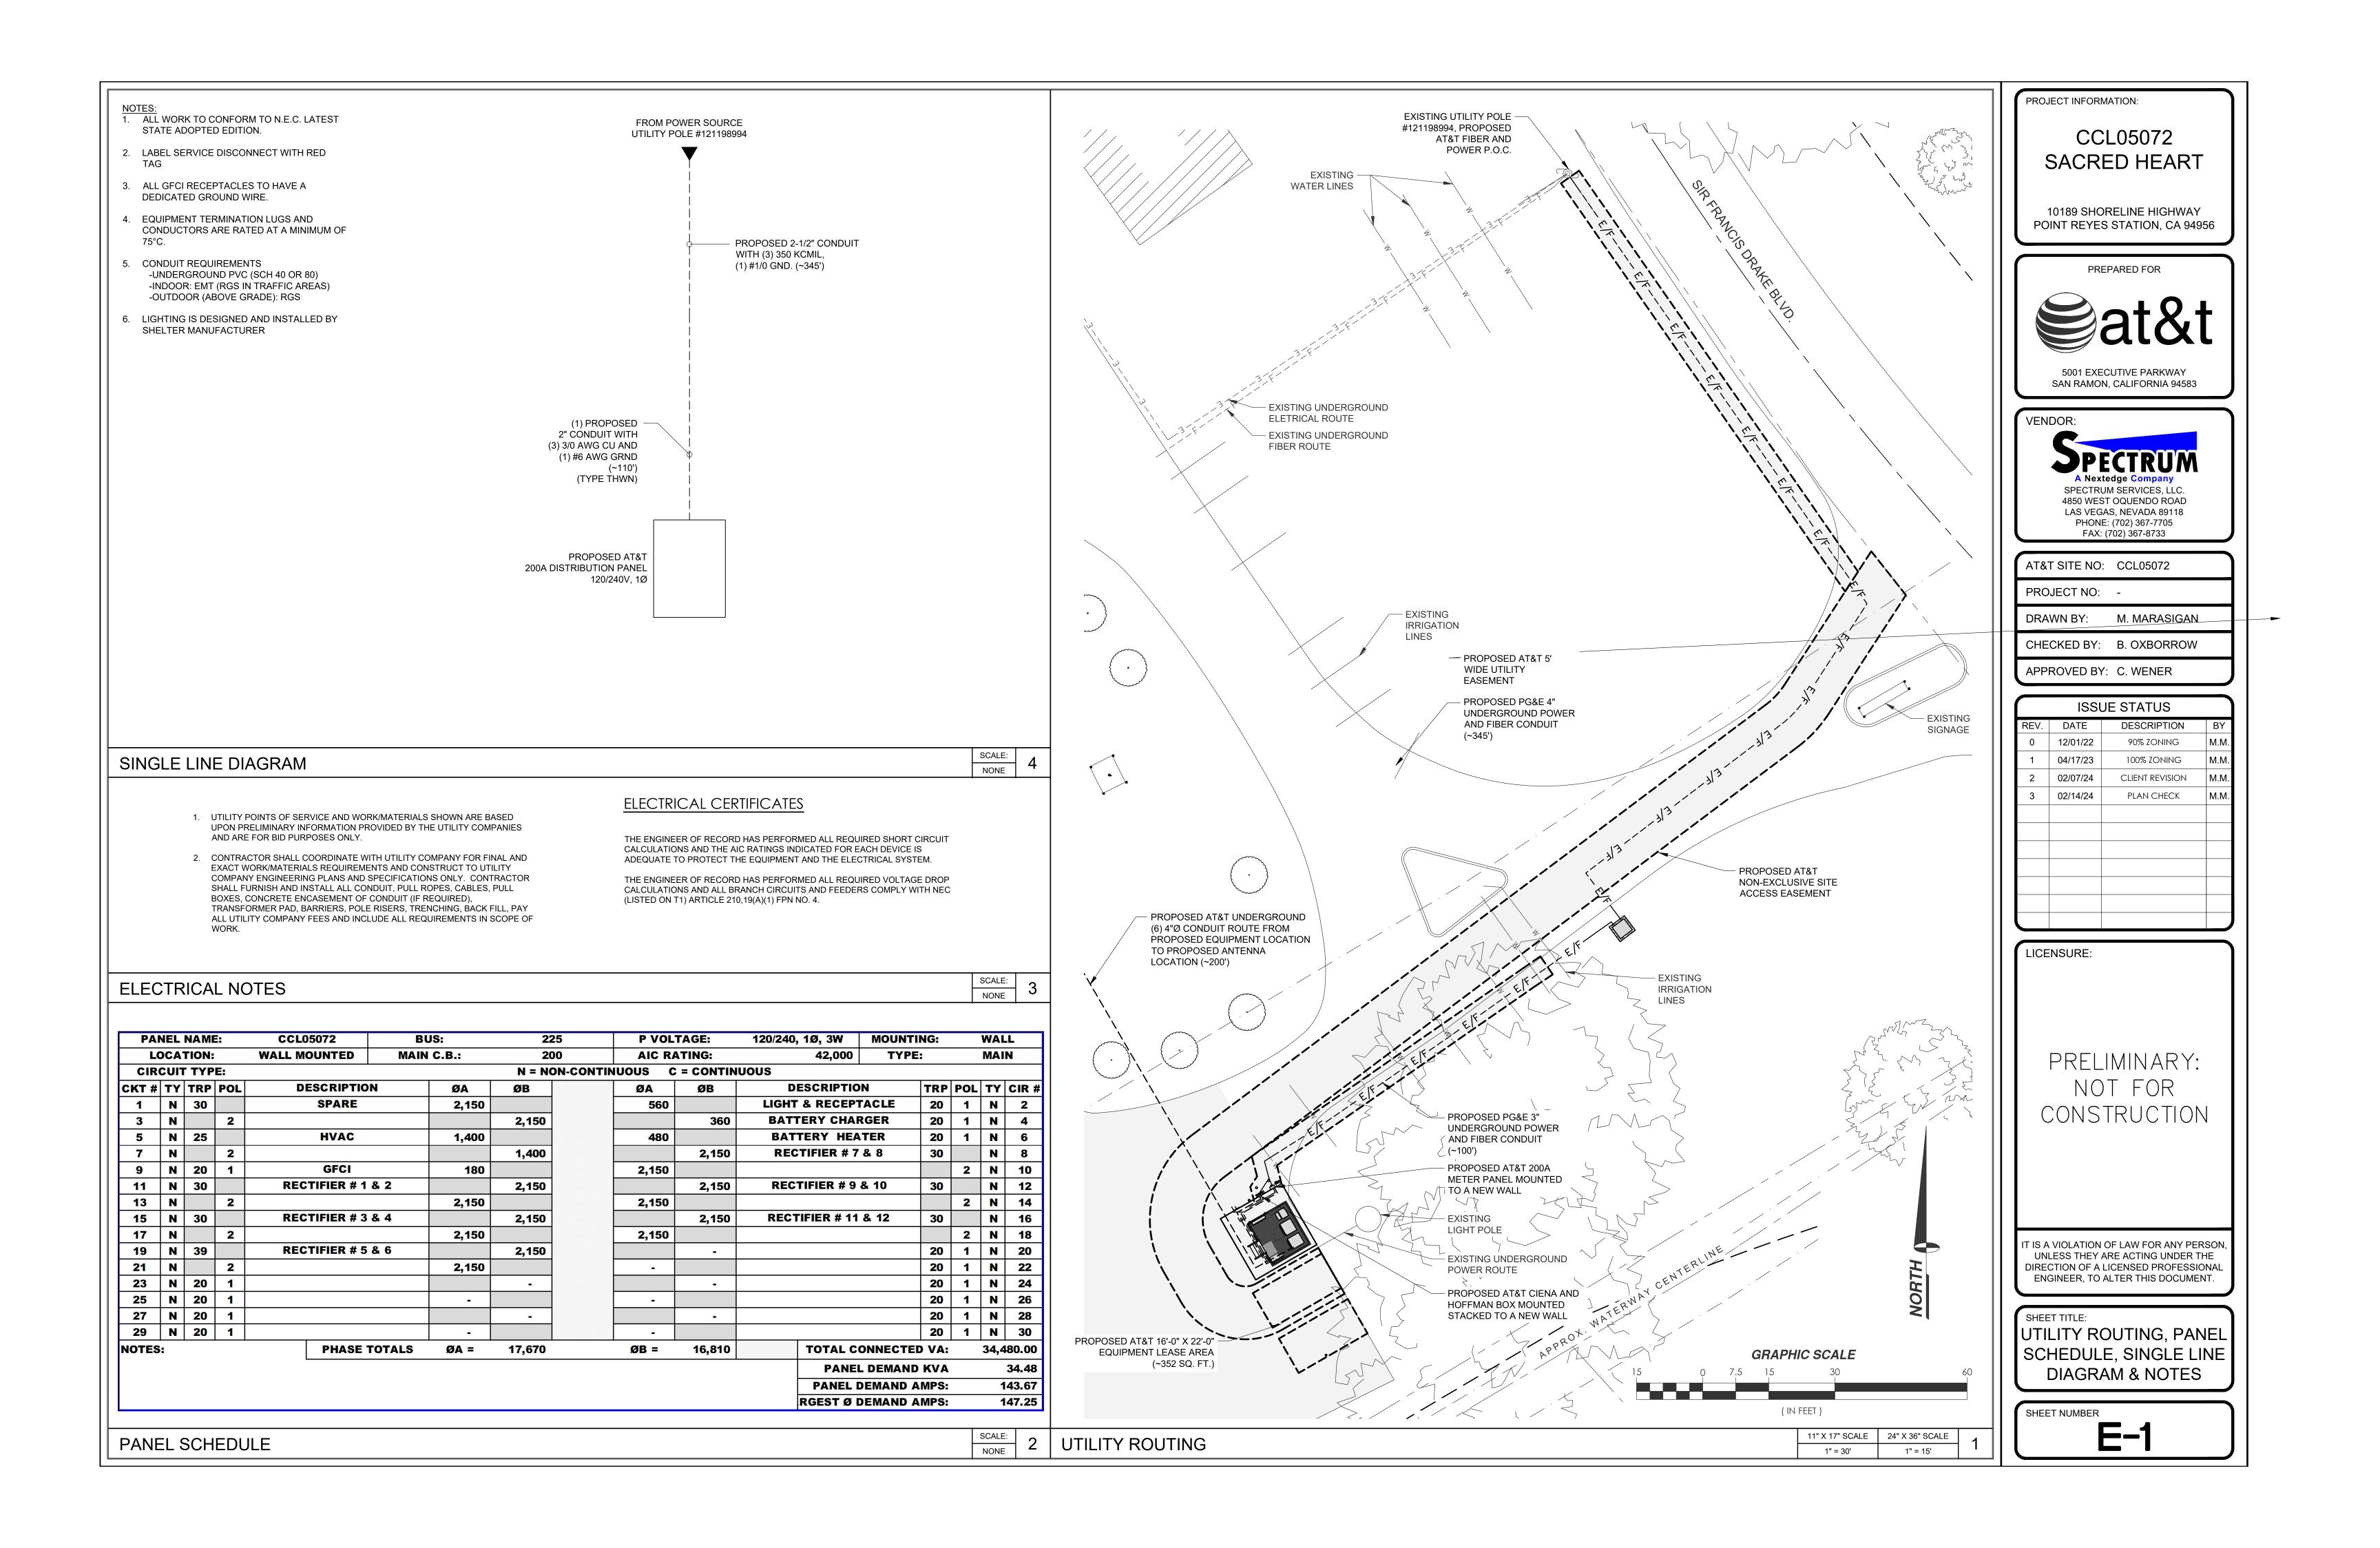

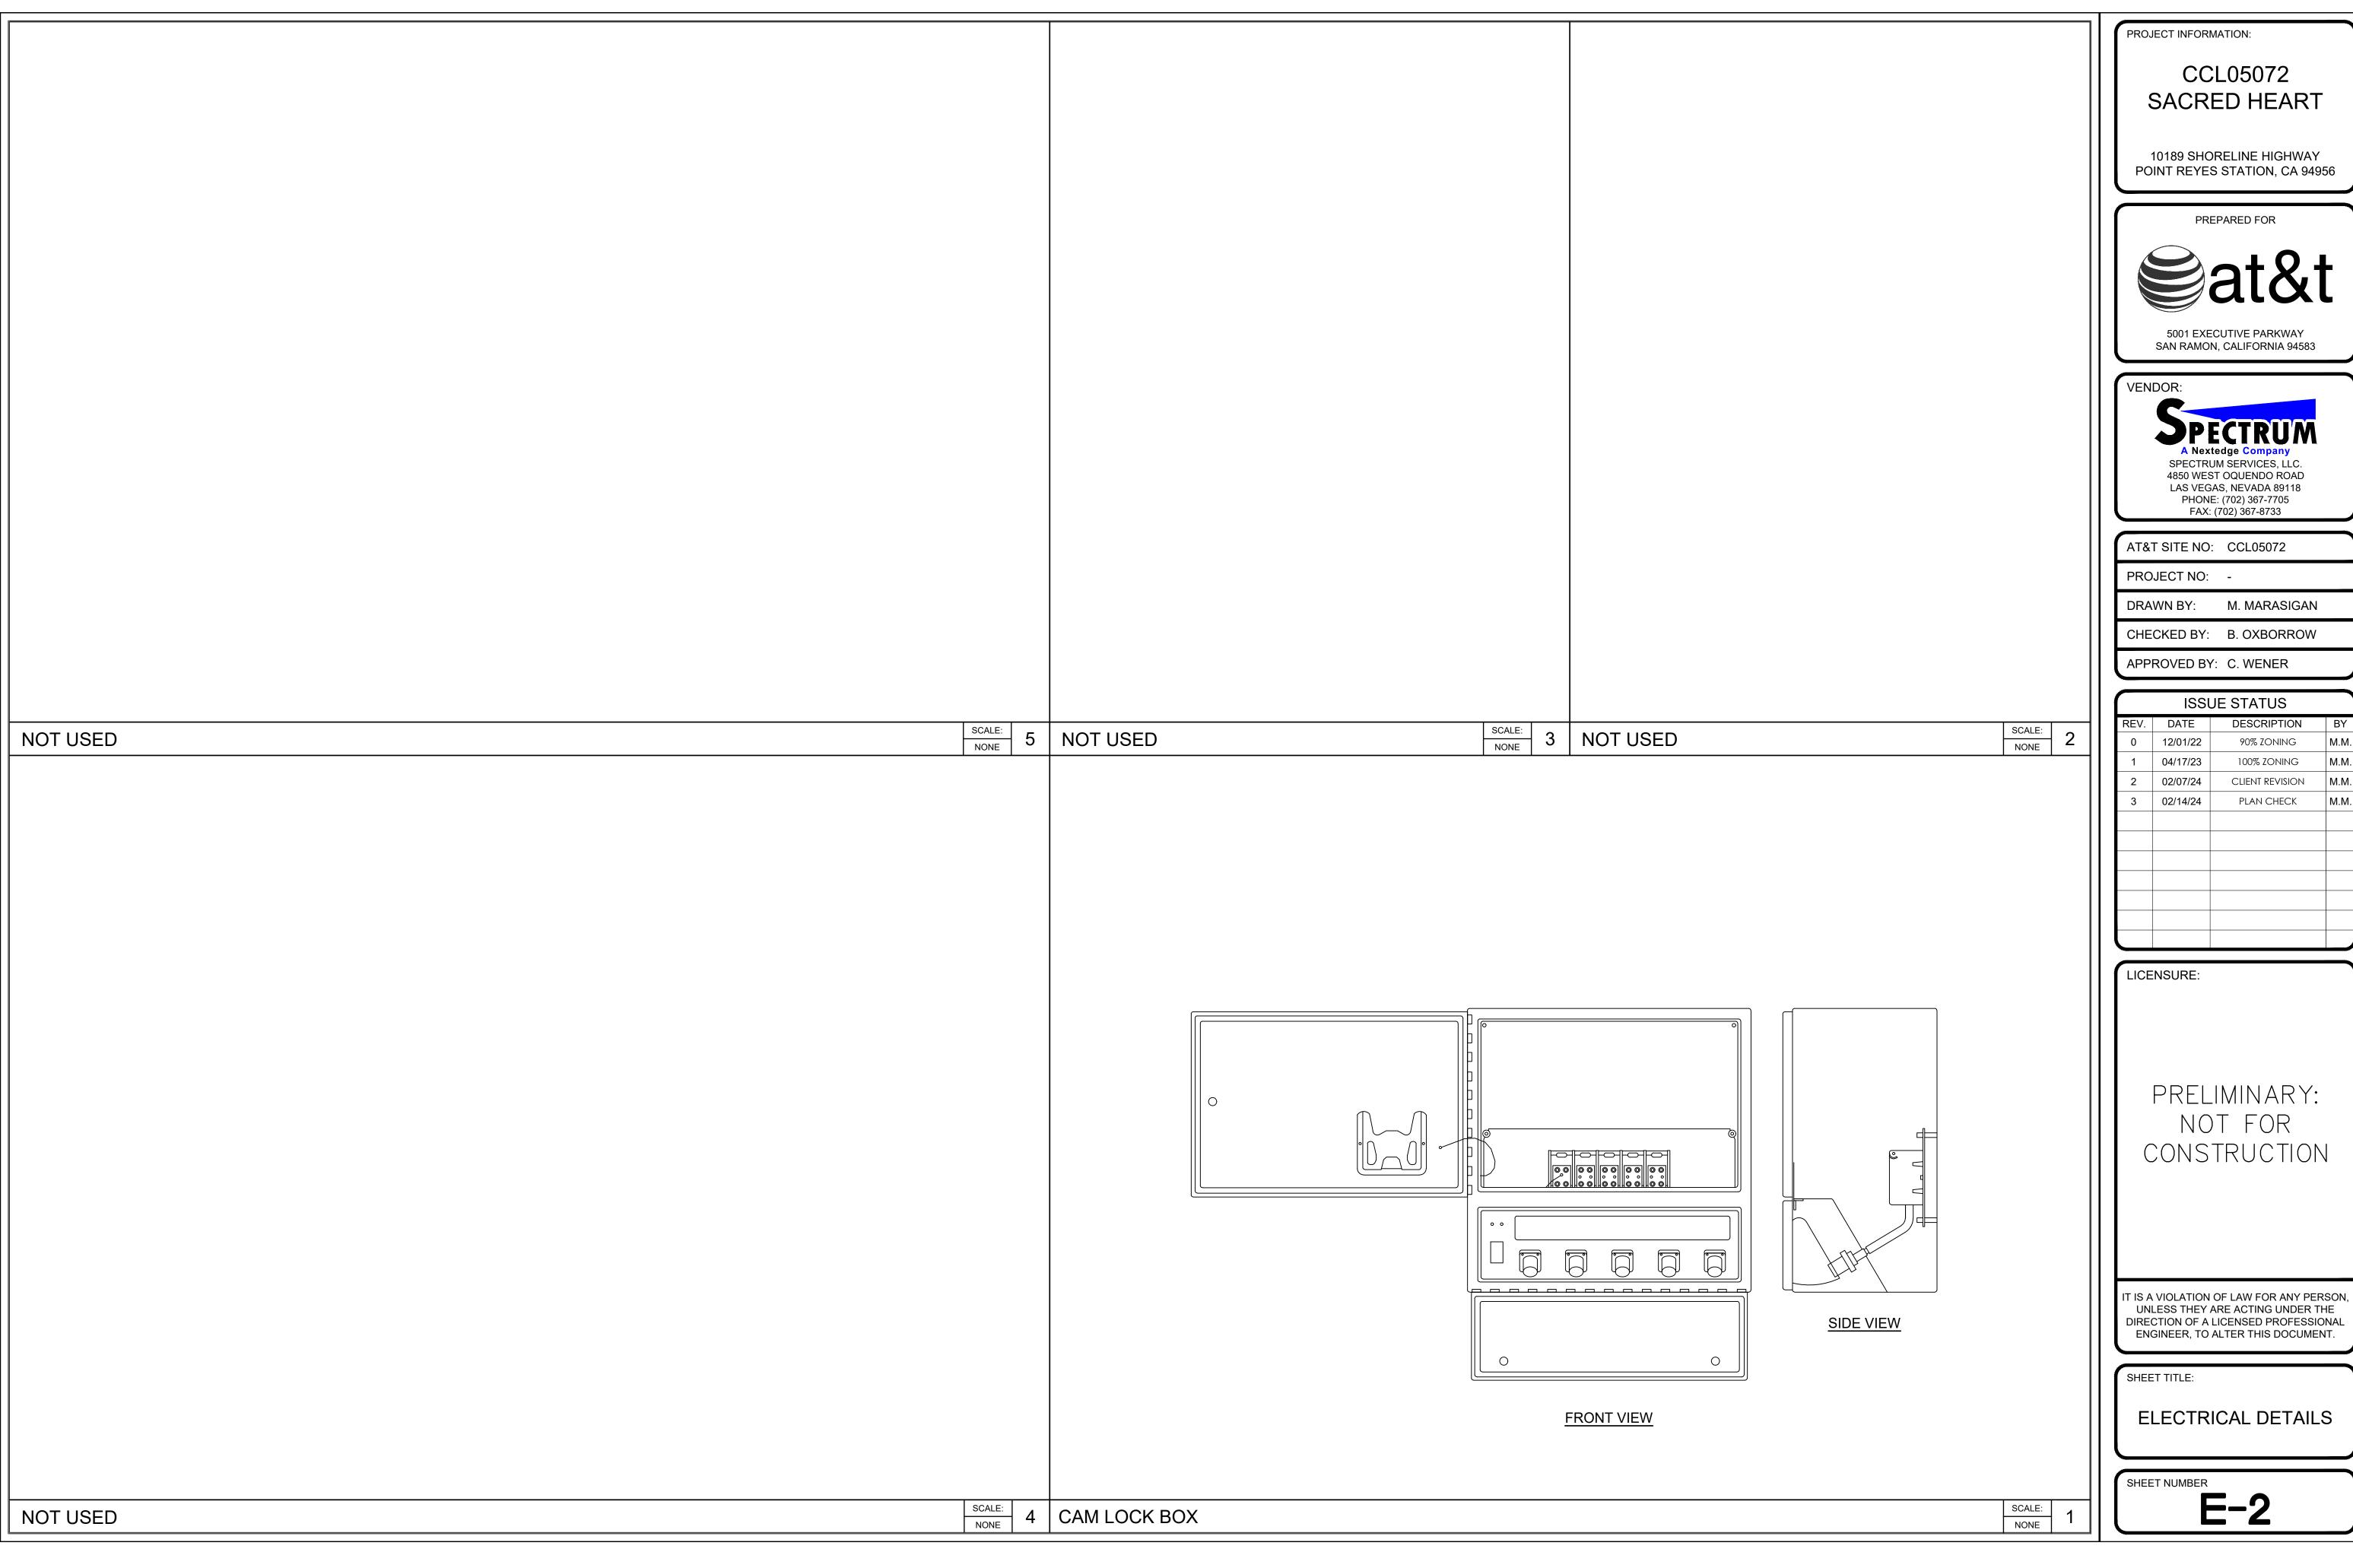

ISSUE STATUS				
REV.	DATE	DESCRIPTION	BY	
0	12/01/22	90% ZONING	M.M.	
1	04/17/23	100% ZONING	M.M.	
2	02/07/24	CLIENT REVISION	M.M.	
3	02/14/24	PLAN CHECK	M.M.	